


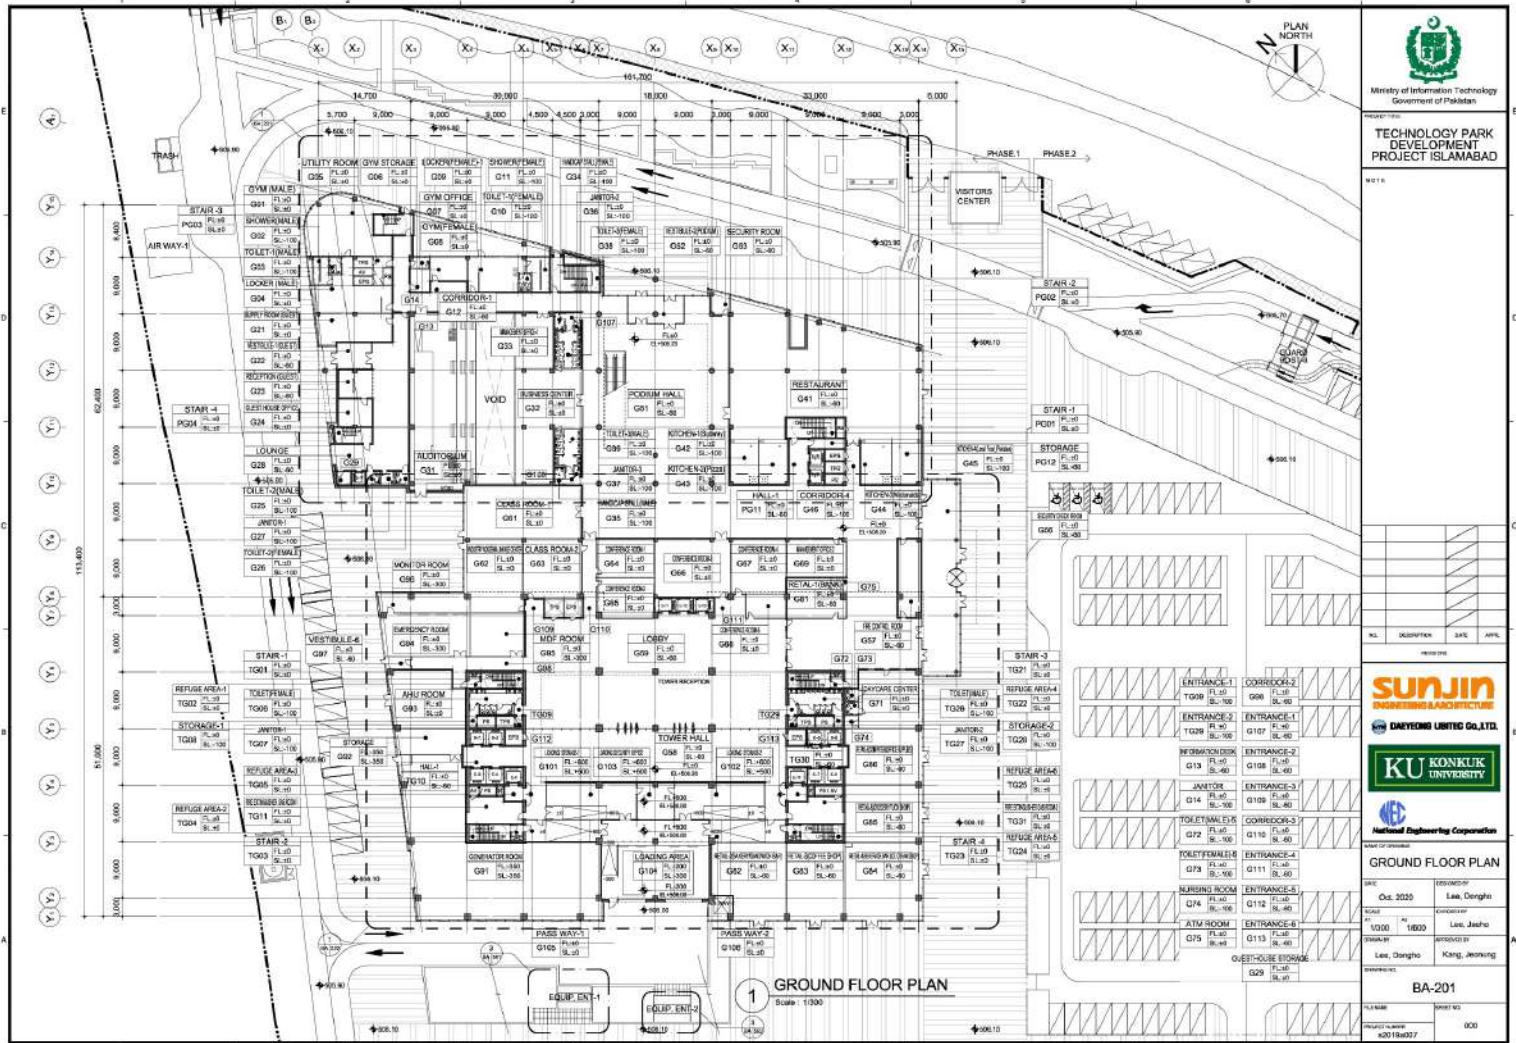

Ministry of Information Technology
Government of Pakistan

TECHNOLOGY PARK
DEVELOPMENT
PROJECT ISLAMABAD

NOTA

SUNJIN
ENGINEERING & ARCHITECTURE

UNIVERSITY OF ENGINEERING & TECHNOLOGY

KU KONKUK
UNIVERSITY


National Engineering Corporation

GROUND FLOOR PLAN

DATE: Oct. 2020
DRAWN BY: Lee, Dongho
CHECKED BY: Lee, Jaehyung
PROJECT NO: 1600
SHEET NO: 000

BA-201

PROJECT NO: 1600
SHEET NO: 000

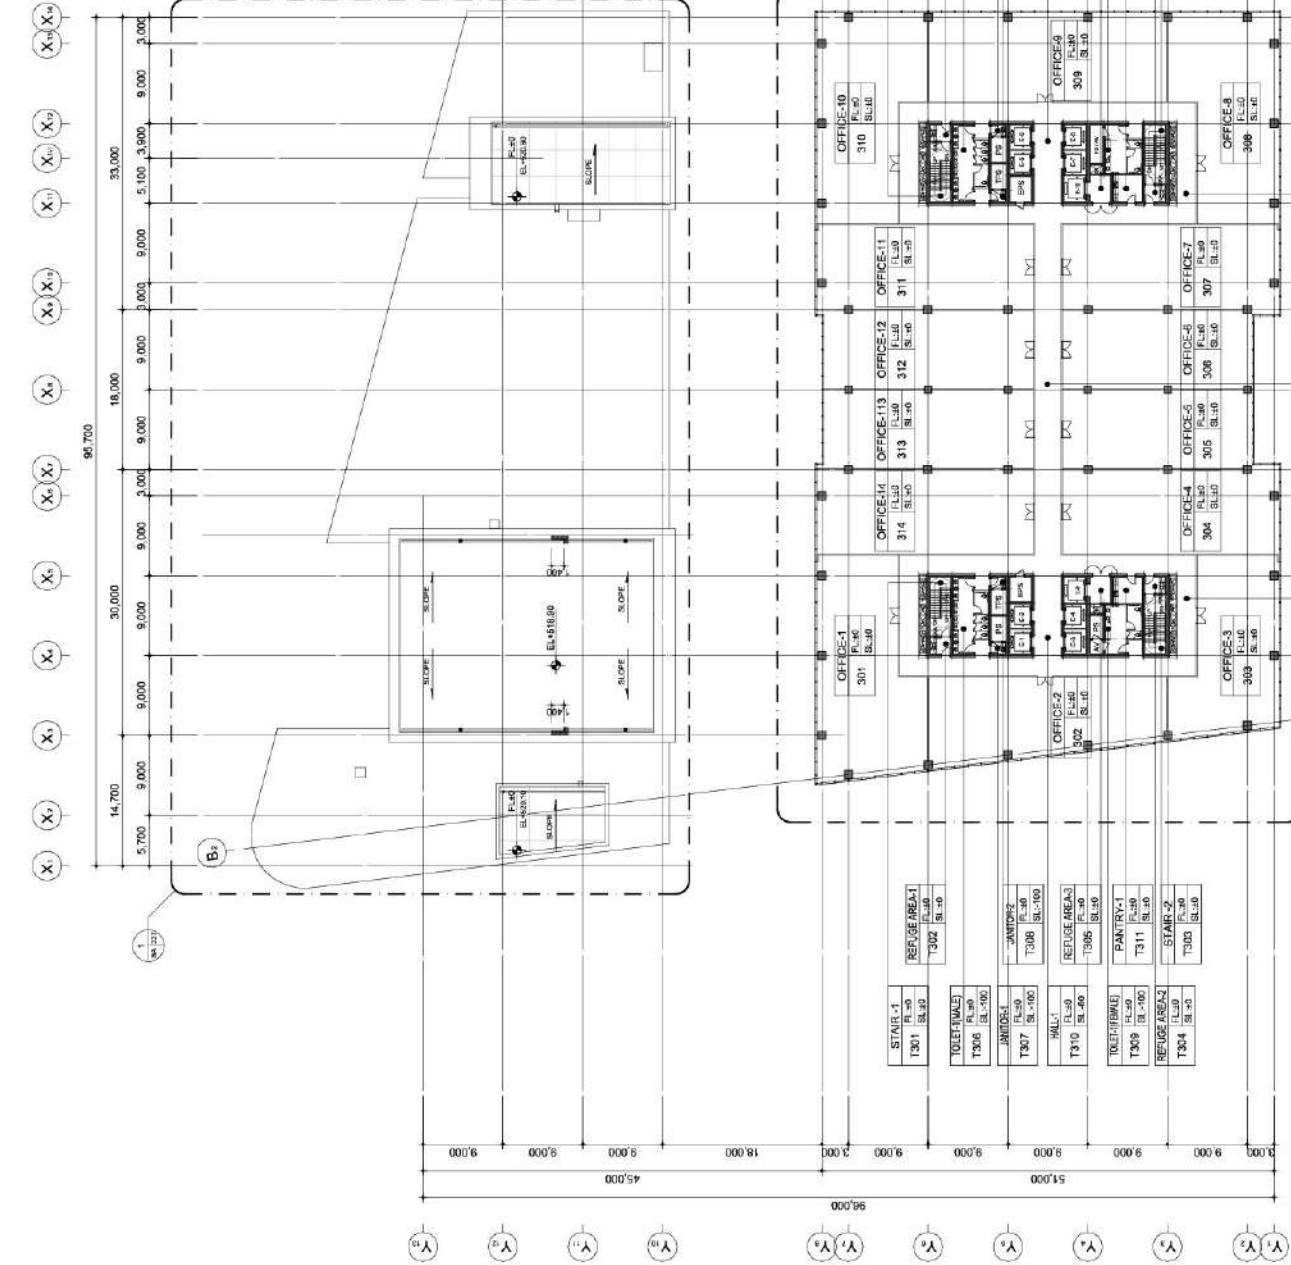

1 3RD FLOOR PLAN
Scale: 1:300

Ministry of Information Technology
Government of Pakistan

TECHNOLOGY PARK
DEVELOPMENT
PROJECT ISLAMABAD

NOTE

NO.	REVISION	DATE	APPV.

SUNJIN
ENGINEERING & ARCHITECTURE

DIARYONG UNITED CO. LTD.



KU KONKUK
UNIVERSITY

National Engineering Corporation

3RD FLOOR PLAN

DATE	Oct. 2020	DESIGNED BY	Lee Dongho
SCALE	1:300	CHECKED BY	Lee Jaehyo
DRAWN BY	Lee Dongho	APPROVED BY	Kang Jeonung
DRAWING NO.	BA-204		

FILE NAME	3RD FLOOR
PROJECT NUMBER	S2018a007
	000

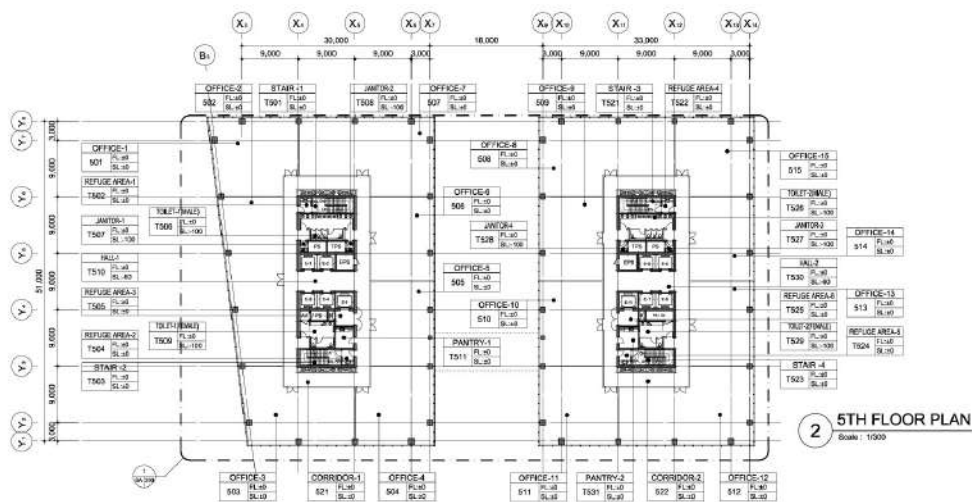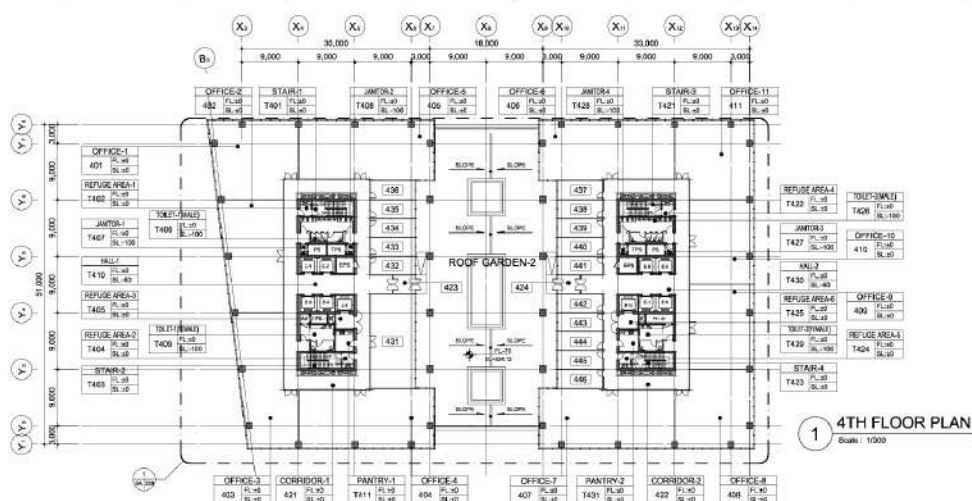

TECHNOLOGY PARK
DEVELOPMENT
PROJECT ISLAMABAD

431	FL 10 S-10	I.C. OFFICE-3	439	FL 10 S-10
432	FL 10 S-10	I.C. OFFICE-1	440	FL 10 S-10
433	FL 10 S-10	I.C. OFFICE-2	441	FL 10 S-10
434	FL 10 S-10	I.C. OFFICE-3	442	FL 10 S-10
435	FL 10 S-10	I.C. OFFICE-4	443	FL 10 S-10
436	FL 10 S-10	I.C. OFFICE-5	444	FL 10 S-10
437	FL 10 S-10	I.C. OFFICE-6	445	FL 10 S-10
438	FL 10 S-10	I.C. OFFICE-7	446	FL 10 S-10

NO.	DESCRIPTION	DATE	AMOUNT



4. 5TH FLOOR PLANS

DATE Oct. 2020		DESIGNED BY Lee, Dongho	
SCALE A1 1/300		CHECKED BY Lee, Jaeho 1/300	
DRAWN BY Lee, Dongho		APPROVED BY Kang, Jeonung	
DRAWING NO. BA-205			
FILE NAME		SHEET NO. 000	
PROJECT NUMBER			



Ministry of Information Technology
Government of Pakistan


TECHNOLOGY PARK
DEVELOPMENT
PROJECT ISLAMABAD

NOTE




6TH FLOOR PLAN

Scale : 1/300

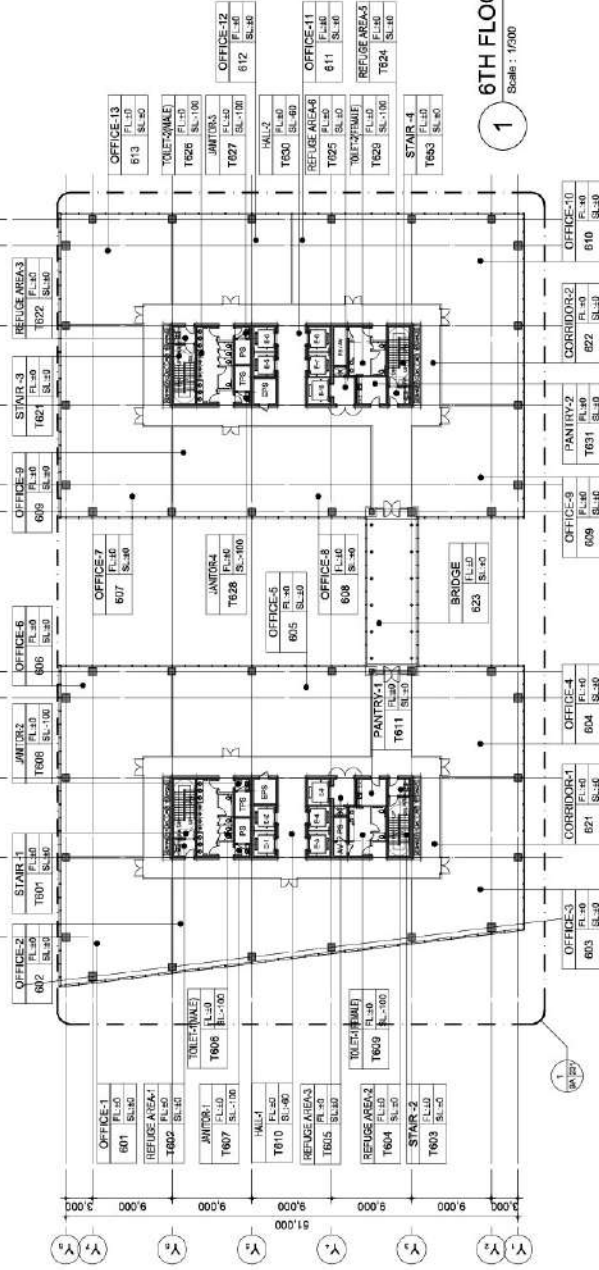

7TH FLOOR PLAN

Scale : 1/300

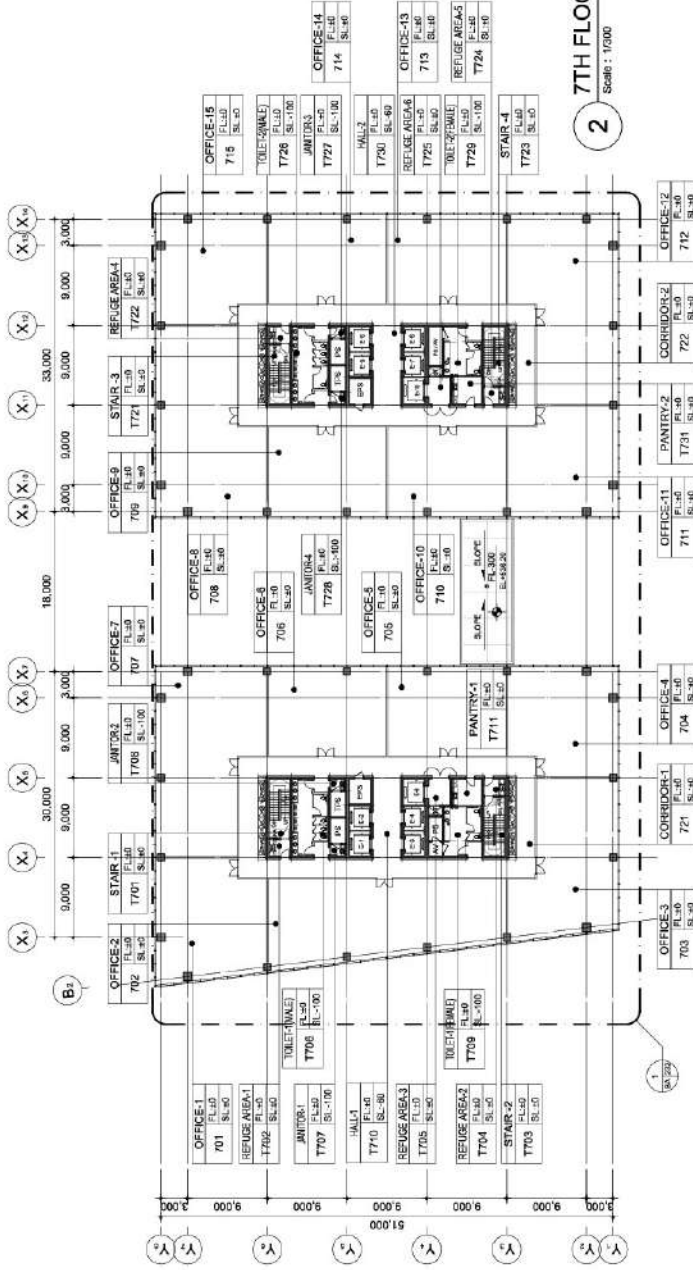

SUNJIN
ENGINEERING & ARCHITECTURE

DAEWOO UNITED CO. LTD.

KU KONKUK
UNIVERSITY

National Engineering Corporation

6, 7TH FLOOR PLANS

DATE: Oct. 2020

SCALE: 1/300

DRAWN BY: Lee Dongho

CHECKED BY: Lee Jaeho

APPROVED BY: Kang Jeonung

DRAWING NO.: BA-206

PROJECT NAME: S-2018-007

000



TECHNOLOGY PARK
DEVELOPMENT
PROJECT ISLAMABAD

NOTE

[illegible]

National Engineering Competition

8, 9TH FLOOR PLANS

1986	1987	1988	2393	2394</
------	------	--------

1	2	3	100
---	---	---	---	---	---	---	---	---	----	----	-----


1/300	1/600	Lee, Jazmin
-------	-------	-------------

Lee, Dongho

DA 307

NAME	PROJECT NO.

 s2019a007



8TH FLOOR PLAN

Scale = 1/300


 
9TH FLOOR PLAN

Scale = 1/3000




TECHNOLOGY PARK
DEVELOPMENT
PROJECT ISLAMABAD

NOTE

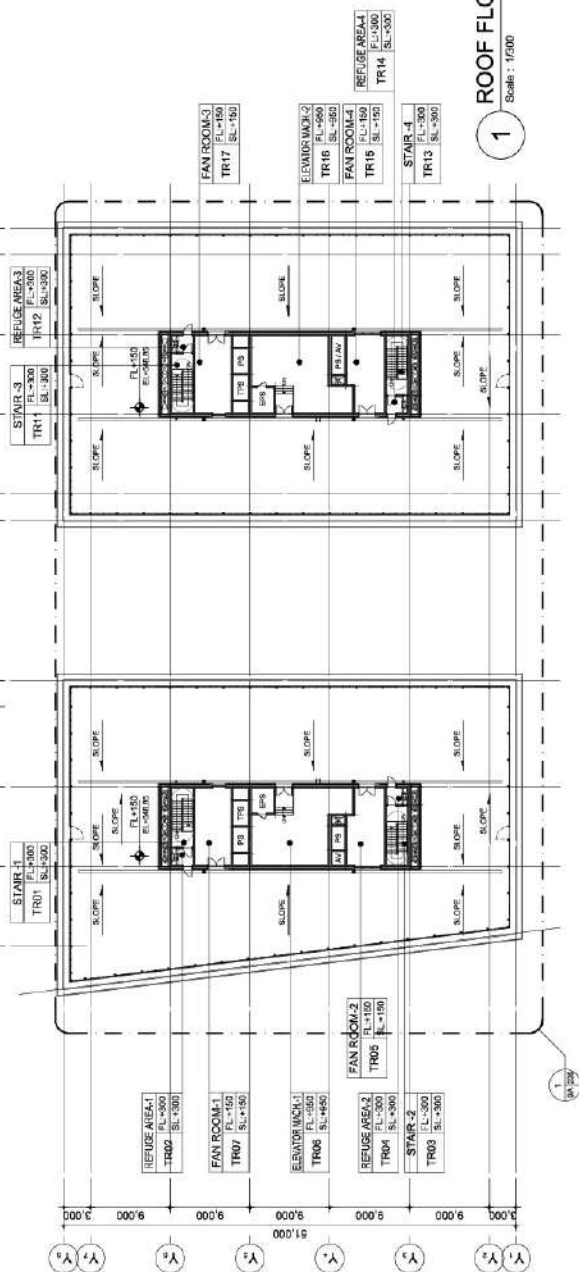

1 ROOF FLOOR PLAN
Scale : 1/300

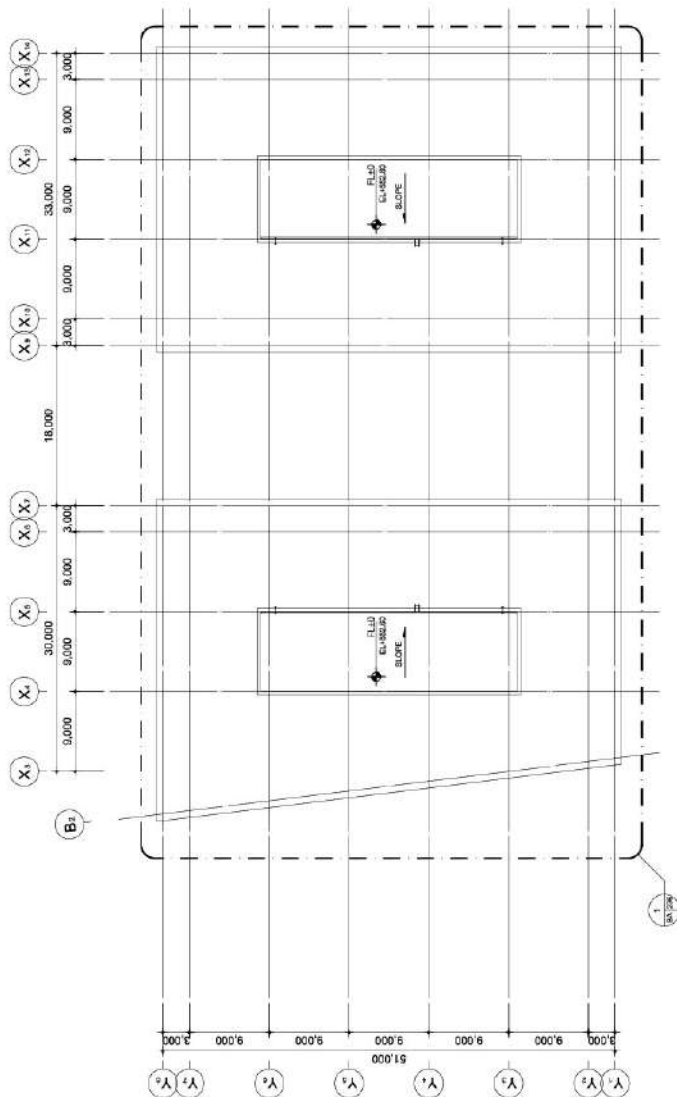

2 ROOF TOP FLOOR PLAN
Scale : 1/300

[illegible][illegible]

National Engineering Corporation

ROOF, ROOF TOP

FLOOR PLANS

DATE	DESIGNED BY
------	-------------

Oct. 2020
Lee, Dangpho[illegible]

SCALES	AL	CHOCOLATE
100	100	100

Lee, Jaehyo	1/800	1/300
-------------	-------	-------

APPROVED BY	
DATE	

Lee, Deborah	Kann, Jeannine
--------------	----------------

Runway, 180m	Runway, 180m
--------------	--------------

DRAWING NO.

BA-208

007-200

DATE	2008.07.11
BY	2008.07.11
NO.	2008.07.11

[illegible]PROJECT NUMBER
-0046-007
000

100561025



TECHNOLOGY PARK
DEVELOPMENT
PROJECT ISLAMABAD



NOTE

[illegible]


National Business Convention

1ST BASEMENT
FLOOR PLAN

DATE	Oct. 2020	REMOVED BY	Lee, Dongho
SCALE	1/300	DATE	1/600
NAME	Lee, Dongho	APPROVED BY	Lee, Jaeho
DRAWING NO.	BA-209		Kang, Jeonung
SHEET NO.	000		
SHEET NUMBER	000		
DATE	2019/01/07		

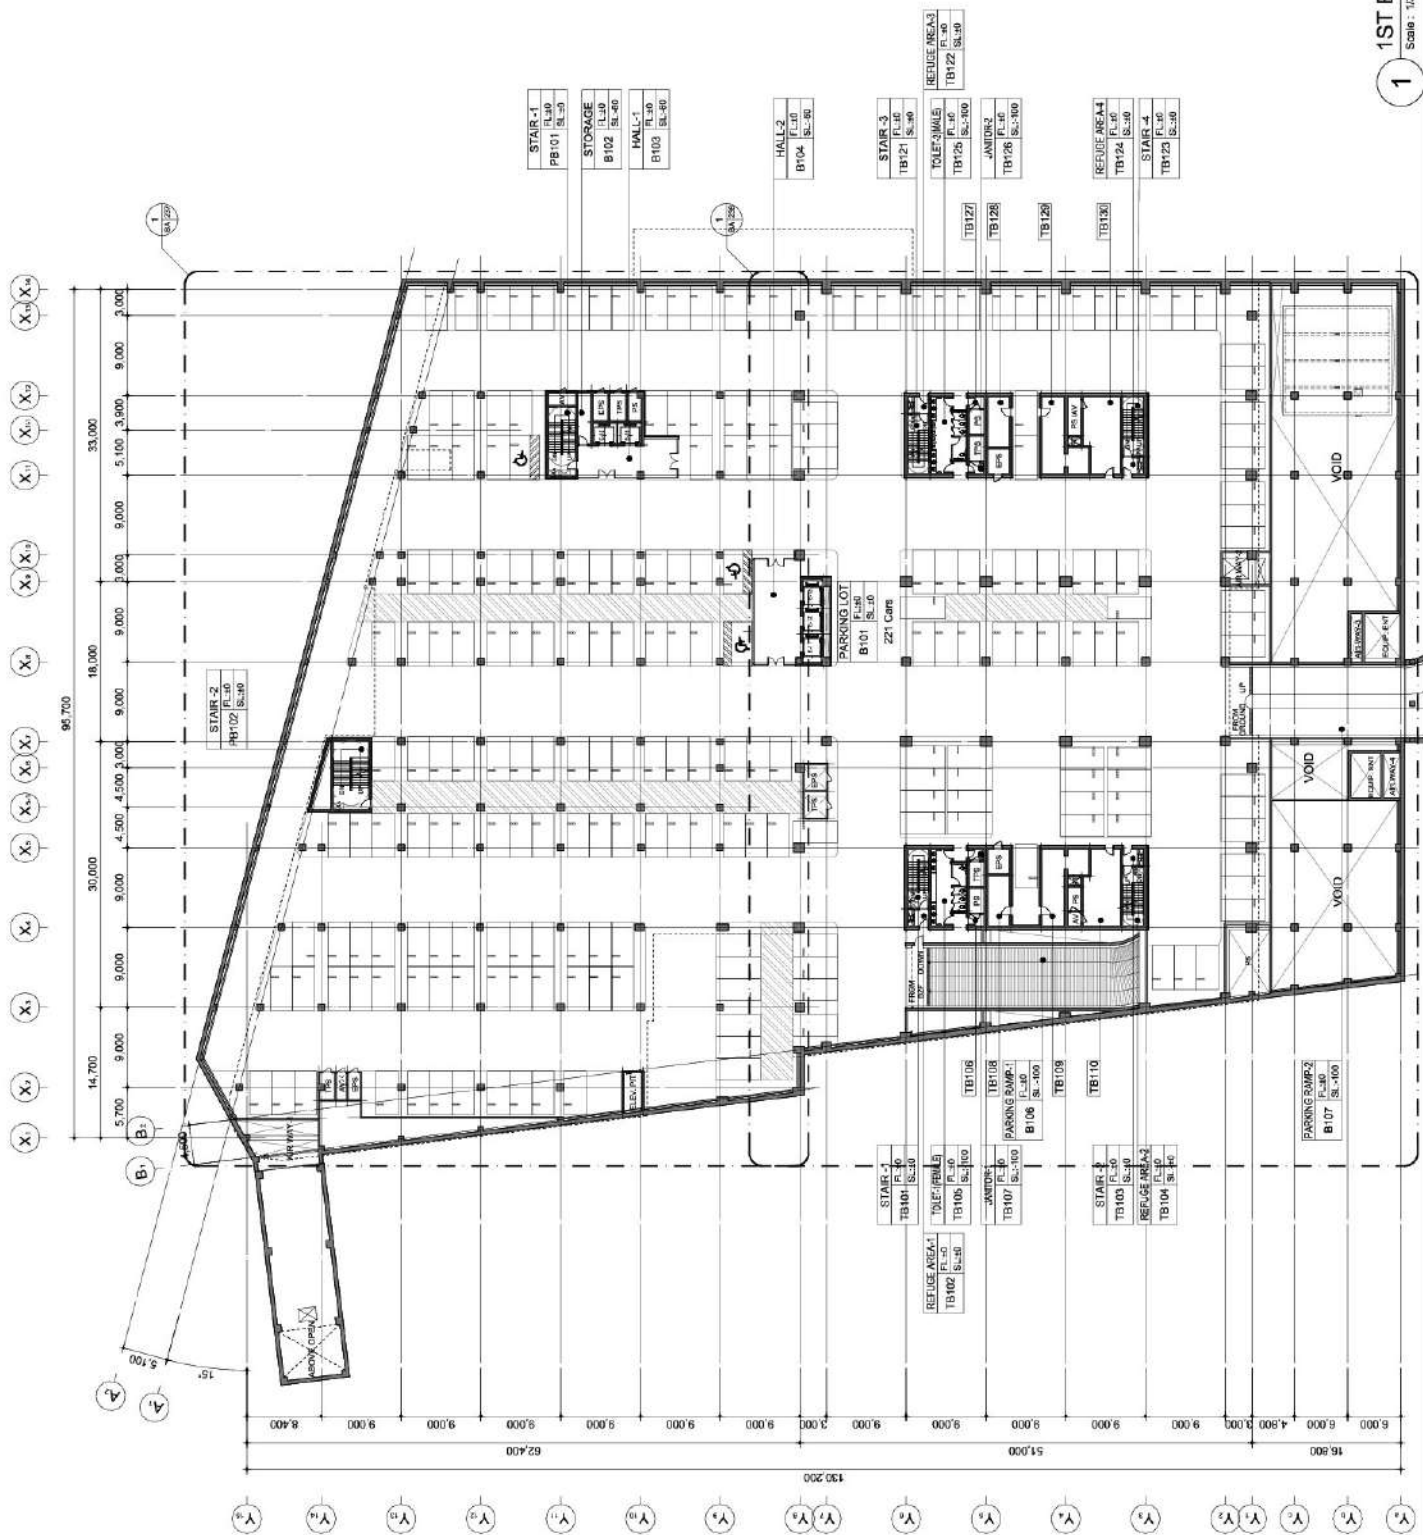 

1
1ST BASEMENT FLOOR PLAN
Scale : 1/300

 

Ministry of Information Technology
Government of Pakistan

TECHNOLOGY PARK
DEVELOPMENT
PROJECT ISLAMABAD

NOTE


[illegible]

2ND BASEMENT
FLOOR PLAN

DATE	OCT. 2020	DESIGNED BY		Lee, Dongho
		SCALE	CH-CH-111P	
	1/320	ALL	1/600	Lee, Jaesho
DRAWN BY		APPROVED BY		Kang, Jeonung
Lee, Dongho				


BA-210

SUBJECT NO.	
SUBJECT NUMBER -000467-0003	000

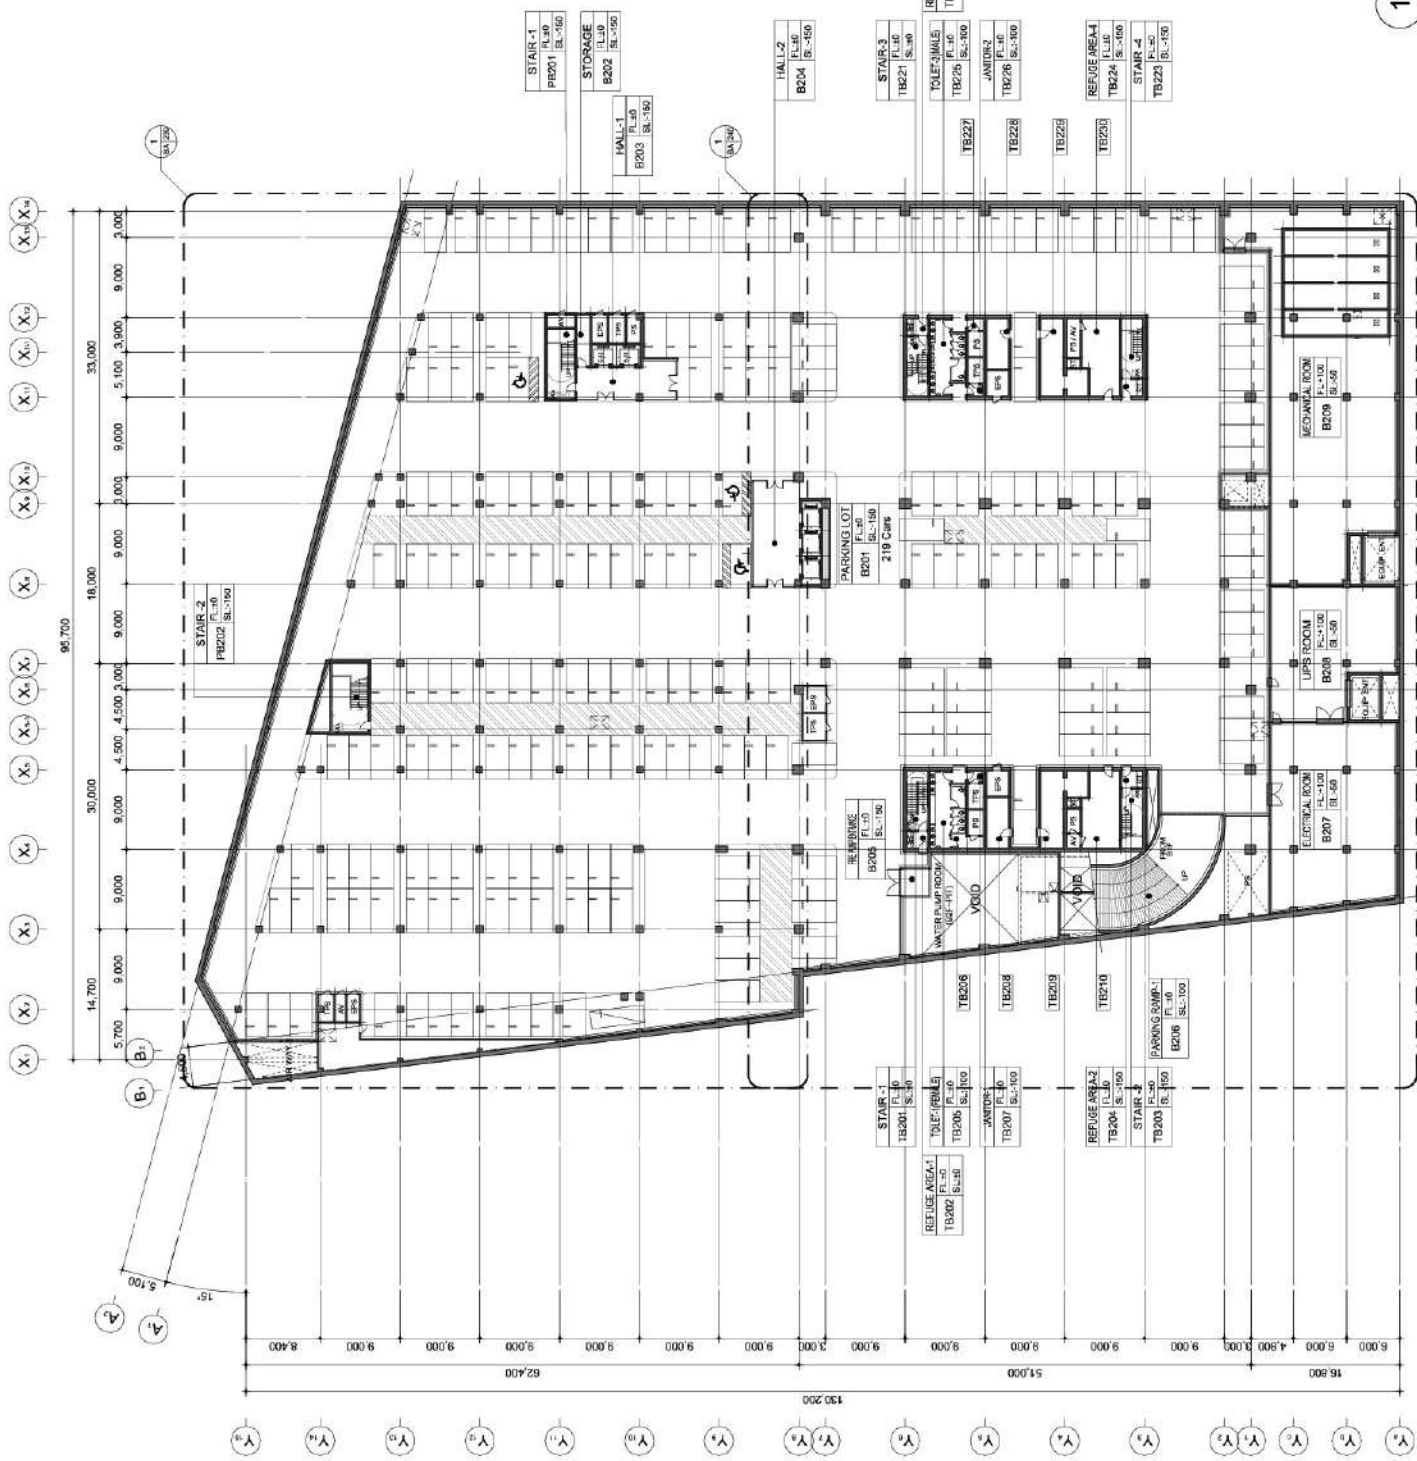

1
2ND BASEMENT FLOOR PLAN

 Scale : 1/300



Ministry of Information Technology
Government of Pakistan

PROJECT TITLE

TECHNOLOGY PARK
DEVELOPMENT
PROJECT ISLAMABAD

NOTE

NO.	REVISION	DATE	APPV.



SUNJIN
ENGINEERING & ARCHITECTURE

DAEWON UNITED CO. LTD.



KU KONKUK
UNIVERSITY



National Engineering Corporation

NAME OF DRAWING

PIT FLOOR PLAN

DATE

Oct. 2020

DESIGNED BY

Lee Dongho

SCALE

1:1000

CHECKED BY

Lee, Jaeho

DATE OF

1/18/20

APPROVED BY

Lee Dongho

DRAWING NO.

BA-211

FILE NAME

PROJECT NUMBER

S20180007

000

1 PIT FLOOR PLAN
Scale : 1:1000



TECHNOLOGY PARK
DEVELOPMENT
PROJECT ISLAMABAD

NOTE

[illegible]

SUNJIN
ENGINEERING & ARCHITECTURE



International Association of Agricultural Engineers (IAAE)

ENLARGED FLOOR PLAN-1


DATE:	Oct. 2020	DESIGNED BY	Lee, Dongho
-------	-----------	-------------	-------------

1/150	1/300	Lee, Jasho
-------	-------	------------

Lee, Dongho	Kang, Jeonung
-------------	---------------

BA-221

PROJECT NUMBER	000
----------------	-----

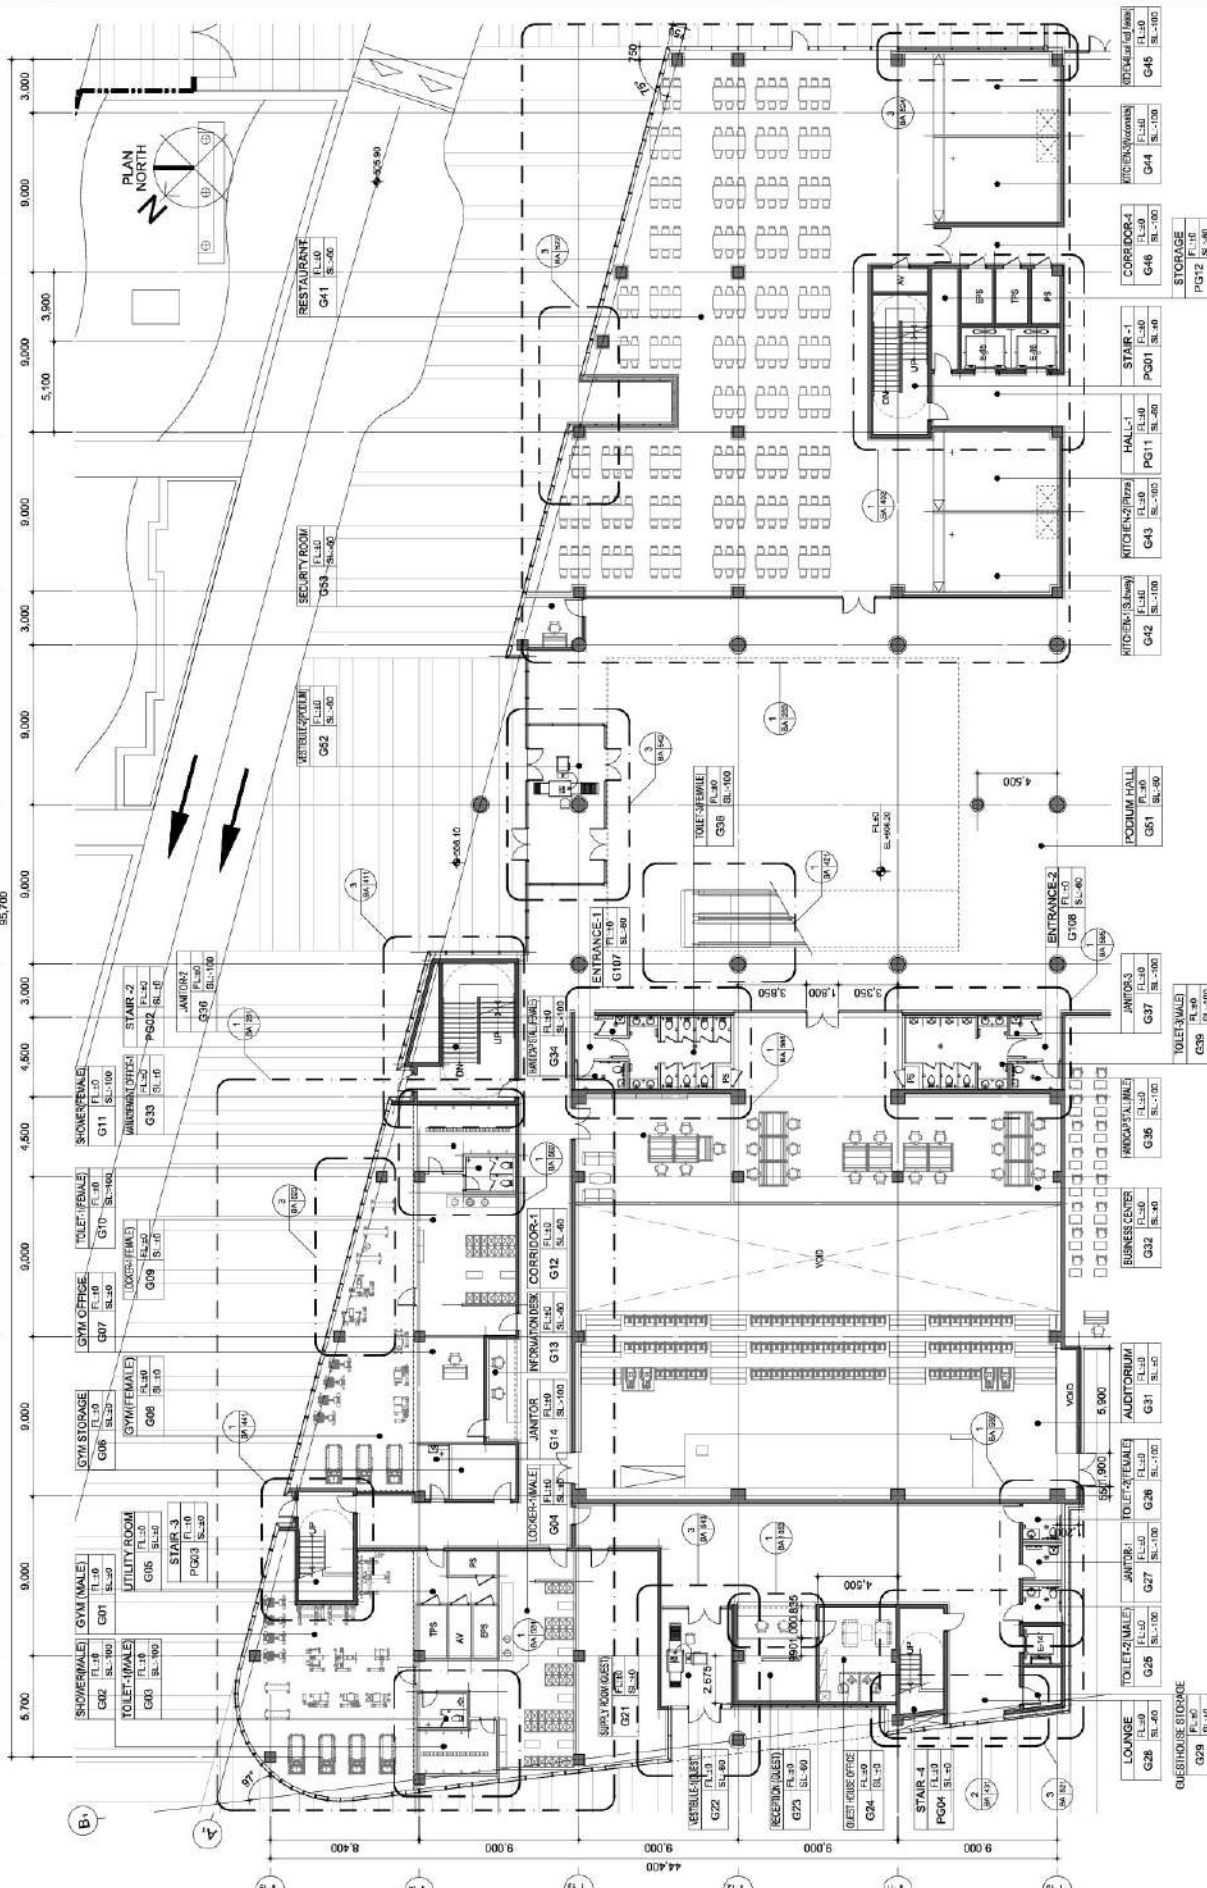

ENLARGED FLOOR PLAN-1(GROUND)

Scale : 1/150



Ministry of Information Technology
Government of Pakistan

TECHNOLOGY PARK
DEVELOPMENT
PROJECT ISLAMABAD

NOTE

SUNJIN
ENGINEERING & ARCHITECTURE

DAEWOO UNITED CO. LTD.


KU KONKUK
UNIVERSITY

National Engineering Corporation

ENLARGED FLOOR PLAN-2
(GROUND)

DATE: Oct. 2020
SCALE: 1/150
DRAWN BY: Lee, Dongho
CHECKED BY: Lee, Jaeho
APPROVED BY: Lee, Dongho
DRAWING NO.: BA-222

PROJECT NUMBER: 2018-007
000

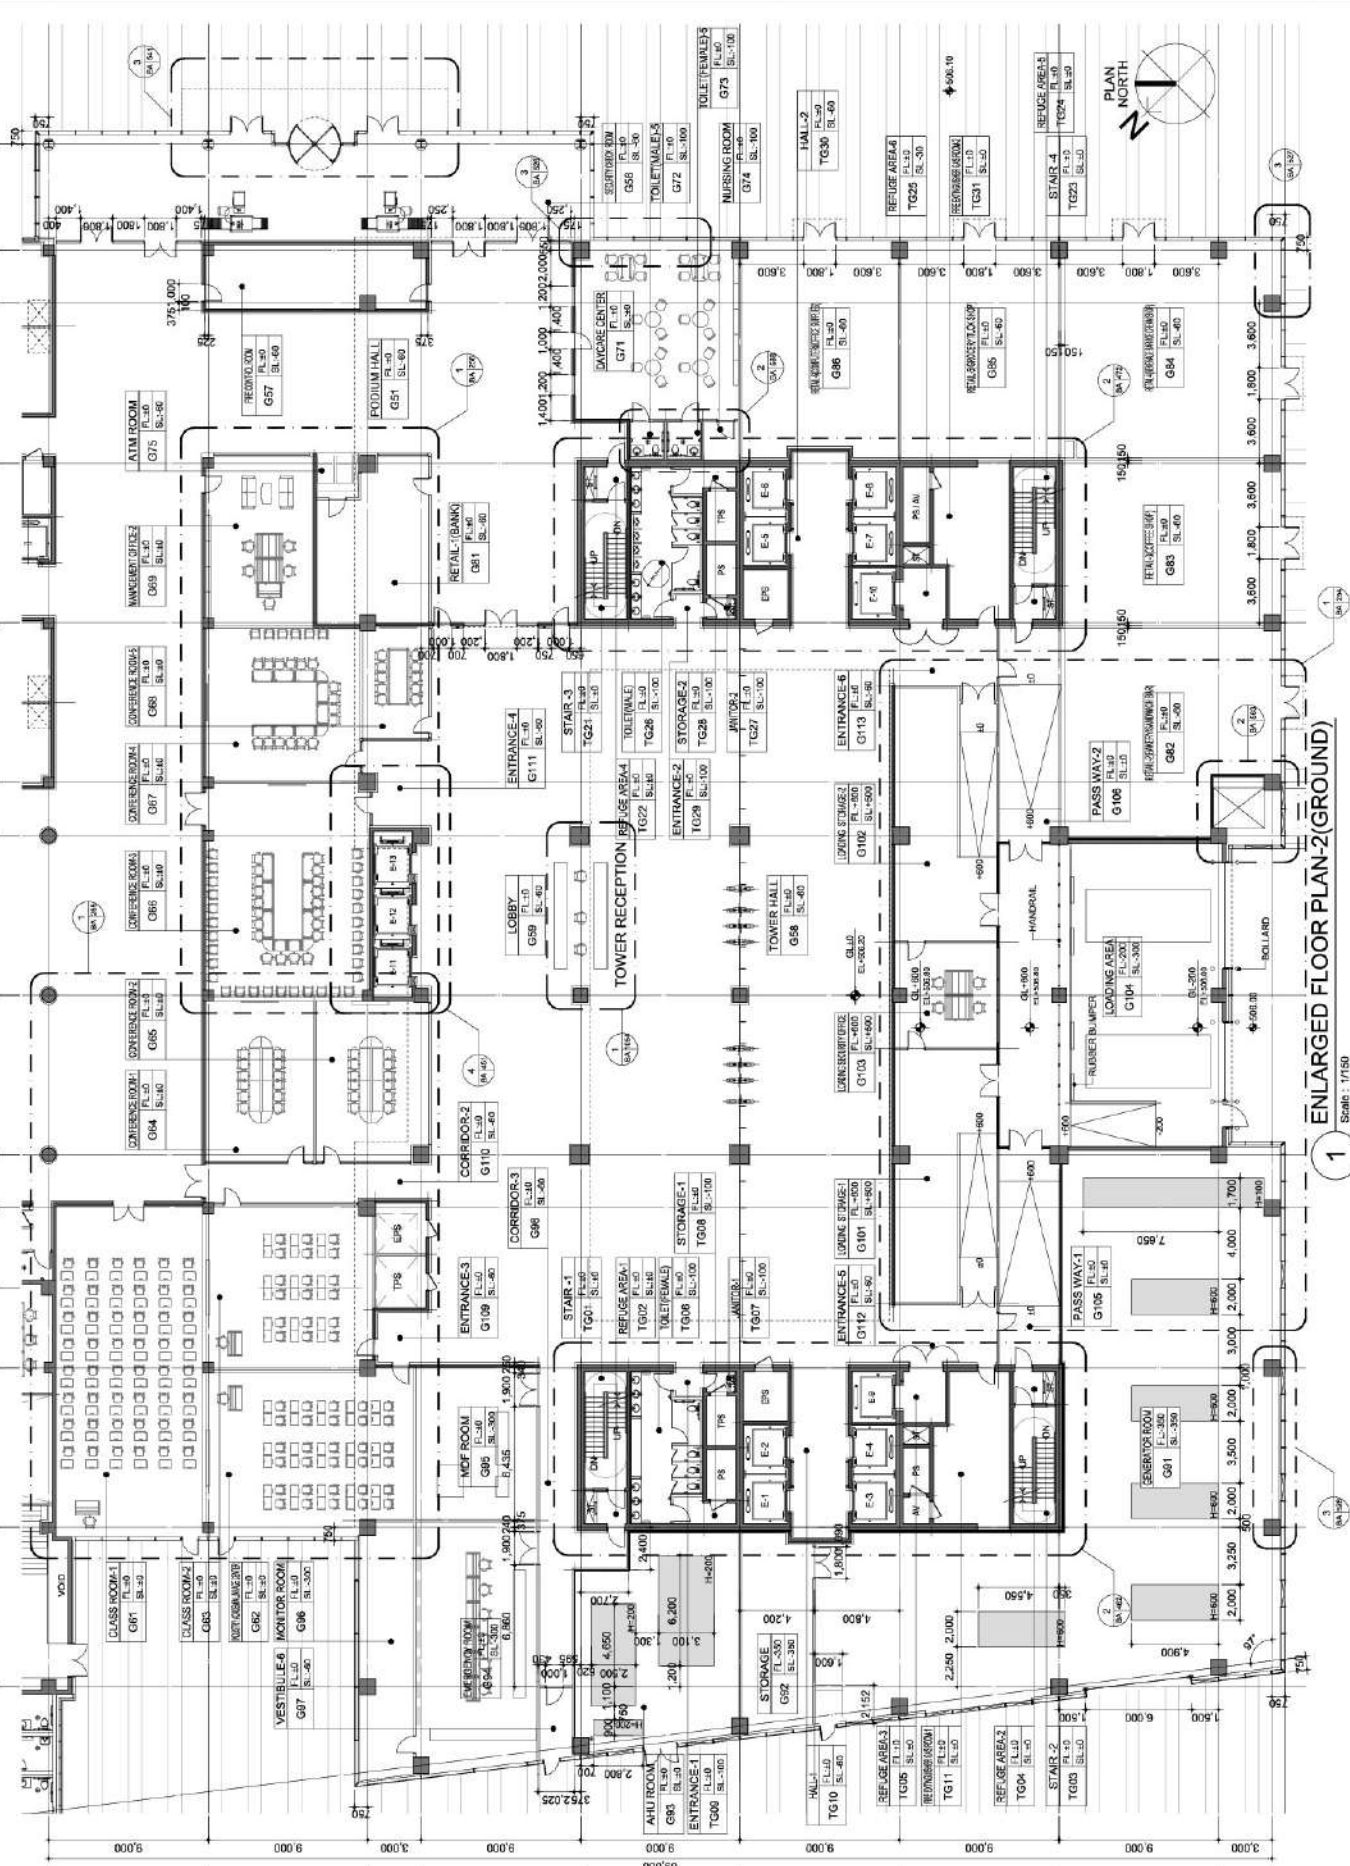

ENLARGED FLOOR PLAN-2(GROUND)
Scale: 1/150



Ministry of Information Technology
Government of Pakistan

TECHNOLOGY PARK
DEVELOPMENT
PROJECT ISLAMABAD

NOTE:

SUNJIN
ENGINEERING & ARCHITECTURE


DAEWOO UNITED CO. LTD.

KU KONKUK
UNIVERSITY

National Engineering Corporation

ENLARGED FLOOR PLAN-1
(1ST)

DATE	Oct. 2020	DESIGNED BY	Lee Dongho
SCALE	1/150	CHECKED BY	Lee, Jaehyo
DRAWN BY	Lee Dongho	APPROVED BY	Kang Jeonung
DRAWING NO.	BA-223		
FILE NAME	BA-223		
PROJECT NUMBER	S2018a007		

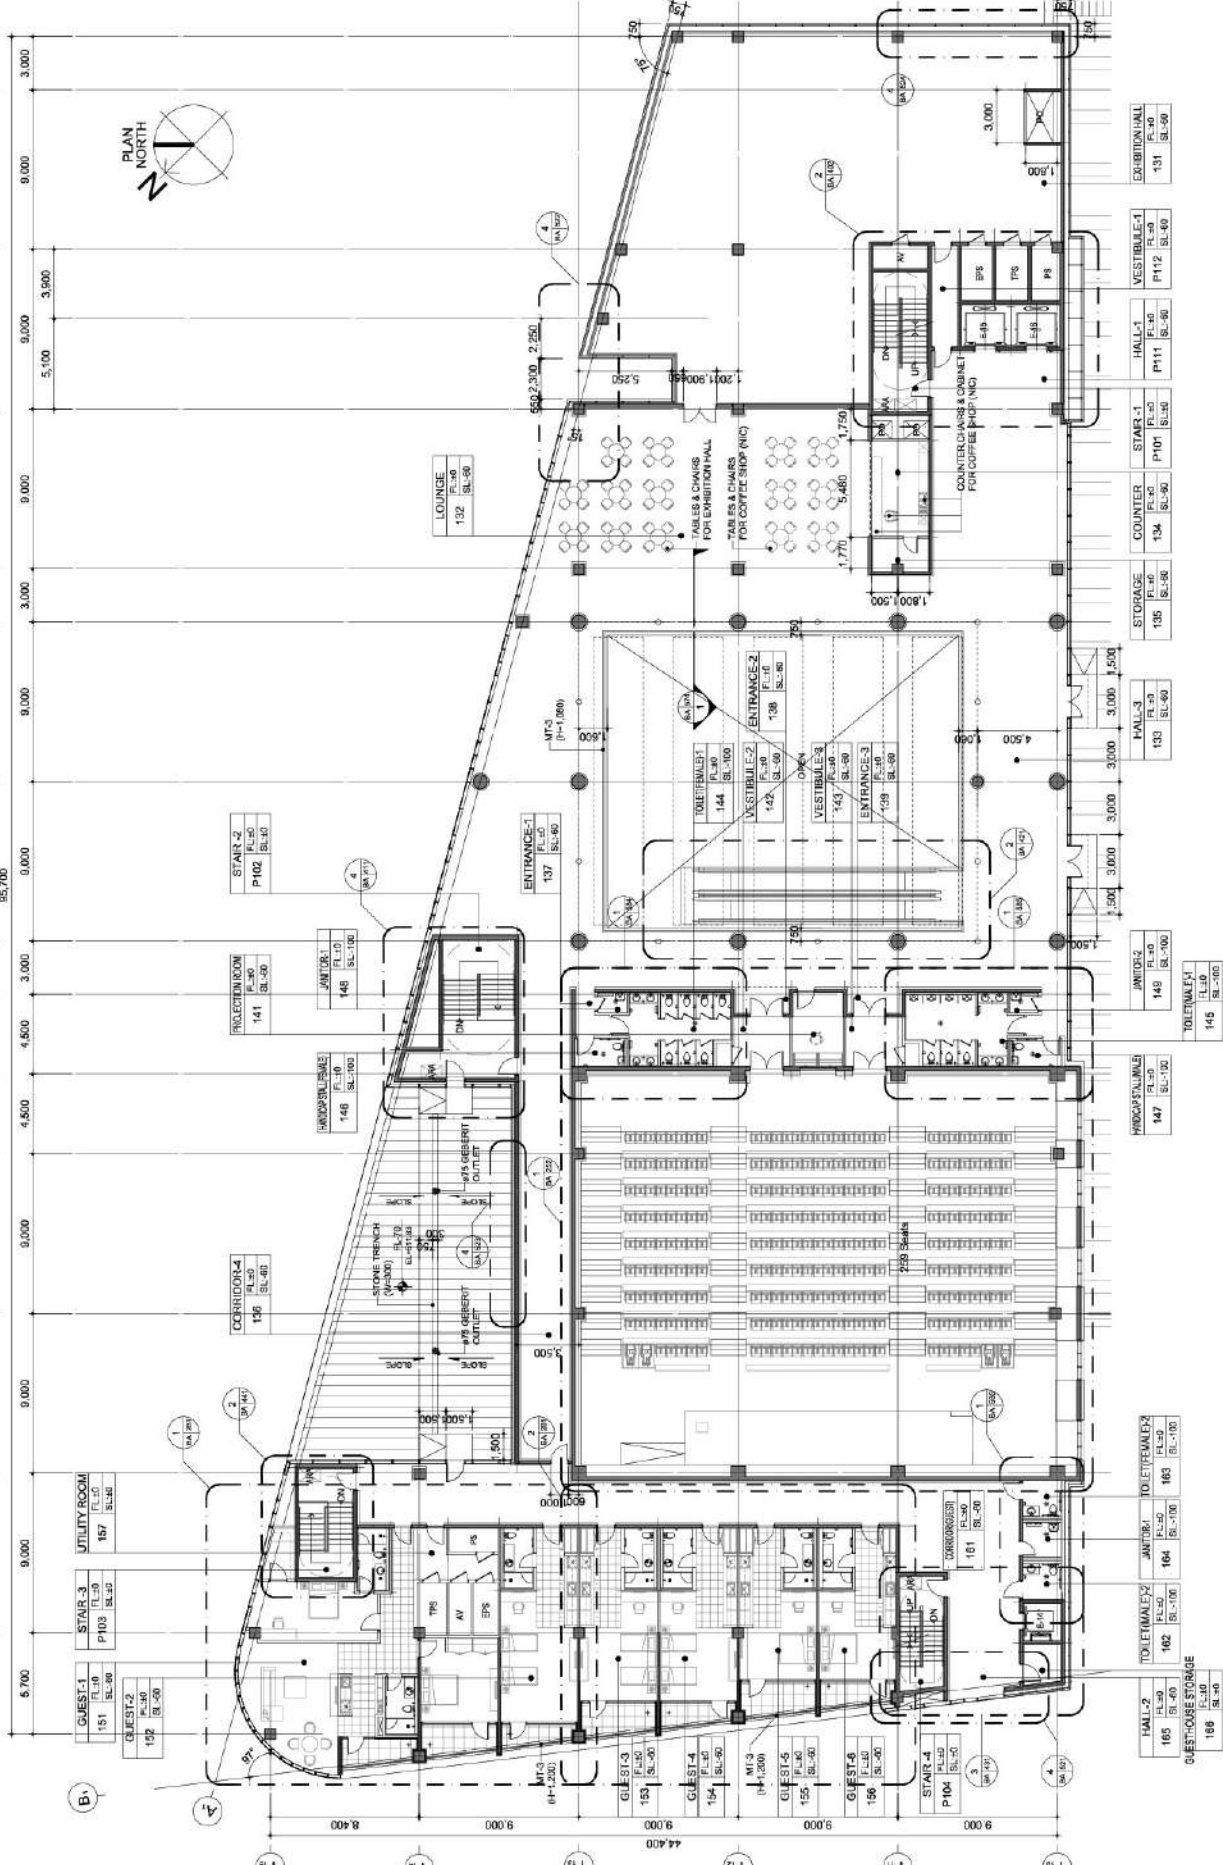

1 ENLARGED FLOOR PLAN-1(1ST)

Scale : 1/150



TECHNOLOGY PARK
DEVELOPMENT
PROJECT ISLAMABAD

NOTE

[illegible]

SUNJIN
ENGINEERING & ARCHITECTURE



National Engineering Corporation

ENLARGED FLOOR PLAN-2
(1ST)


DATE	Oct. 2020	DESIGNED BY	Lee, Dongho
------	-----------	-------------	-------------

DATE	ALL	Lee, Jaeho
1/150	1/300	

APPROVED BY	Kang, Jeonung
MAKED BY	Lee, Dongho

BA-224

E-MAIL	BUDGET NO.
--------	------------

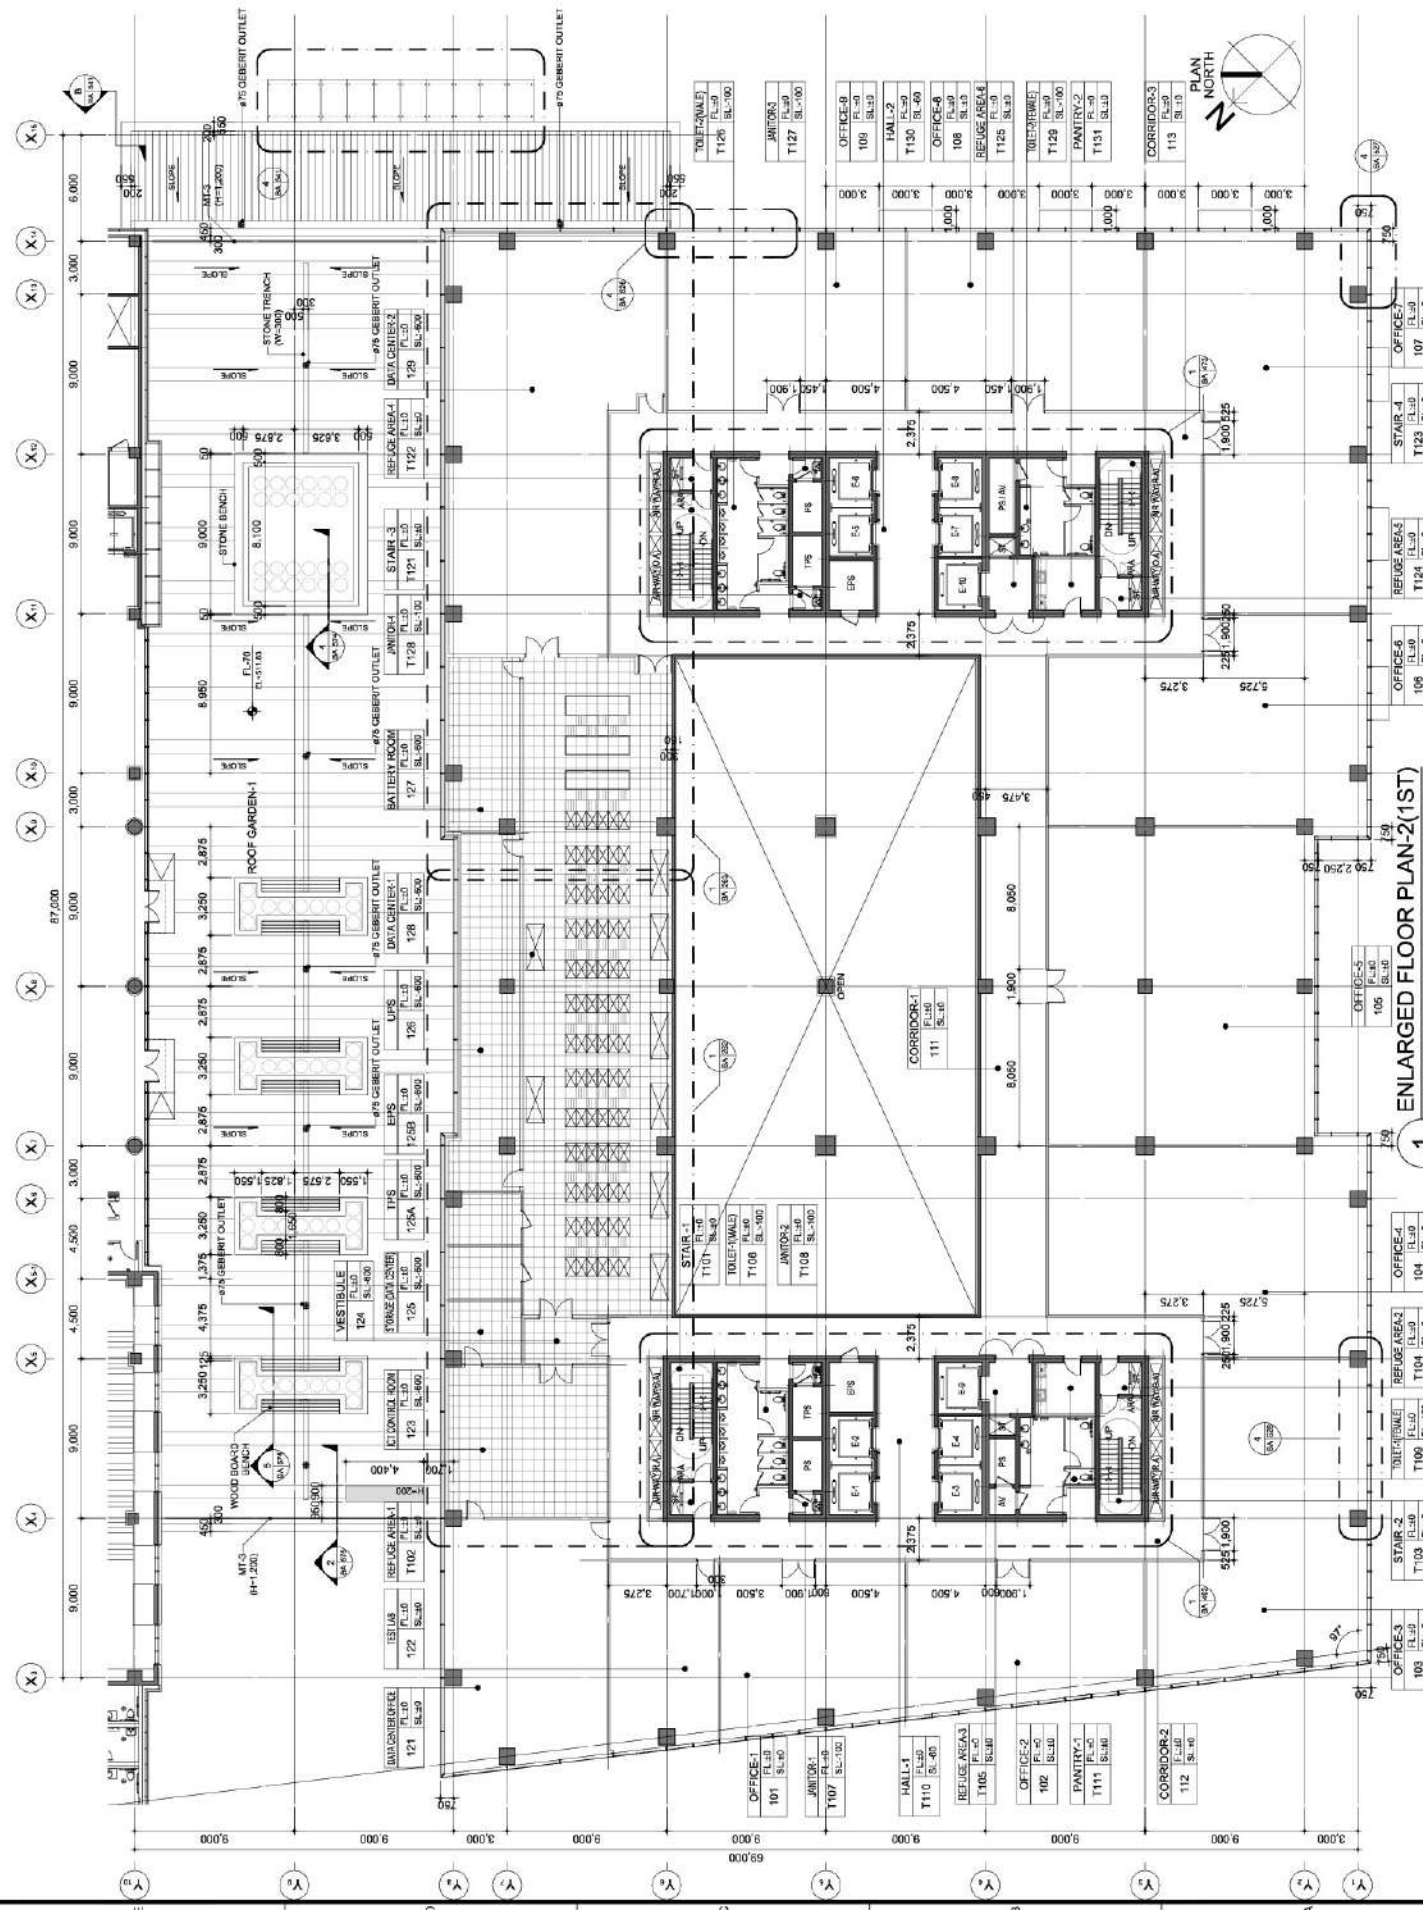



Ministry of Information Technology
Government of Pakistan

PROJECT TITLE

TECHNOLOGY PARK
DEVELOPMENT
PROJECT ISLAMABAD

NOTE

NO.	REVISION	DATE	APPV.

SUNJIN
ENGINEERING & ARCHITECTURE


DAEWONG UNITED CO. LTD.

KU KONKUK UNIVERSITY

National Engineering Corporation


ENLARGED FLOOR PLAN-1
(2ND)

DATE	Oct. 2020	DESIGNED BY	Lee Dongho
SCALE	1/150	CHECKED BY	Lee Jaeha
DRAWN BY	Lee Dongho	APPROVED BY	Kang Jeonung
DRAWING NO.	BA-225	PROJECT NO.	S2019a007
FILE NAME		PLANT NO.	000

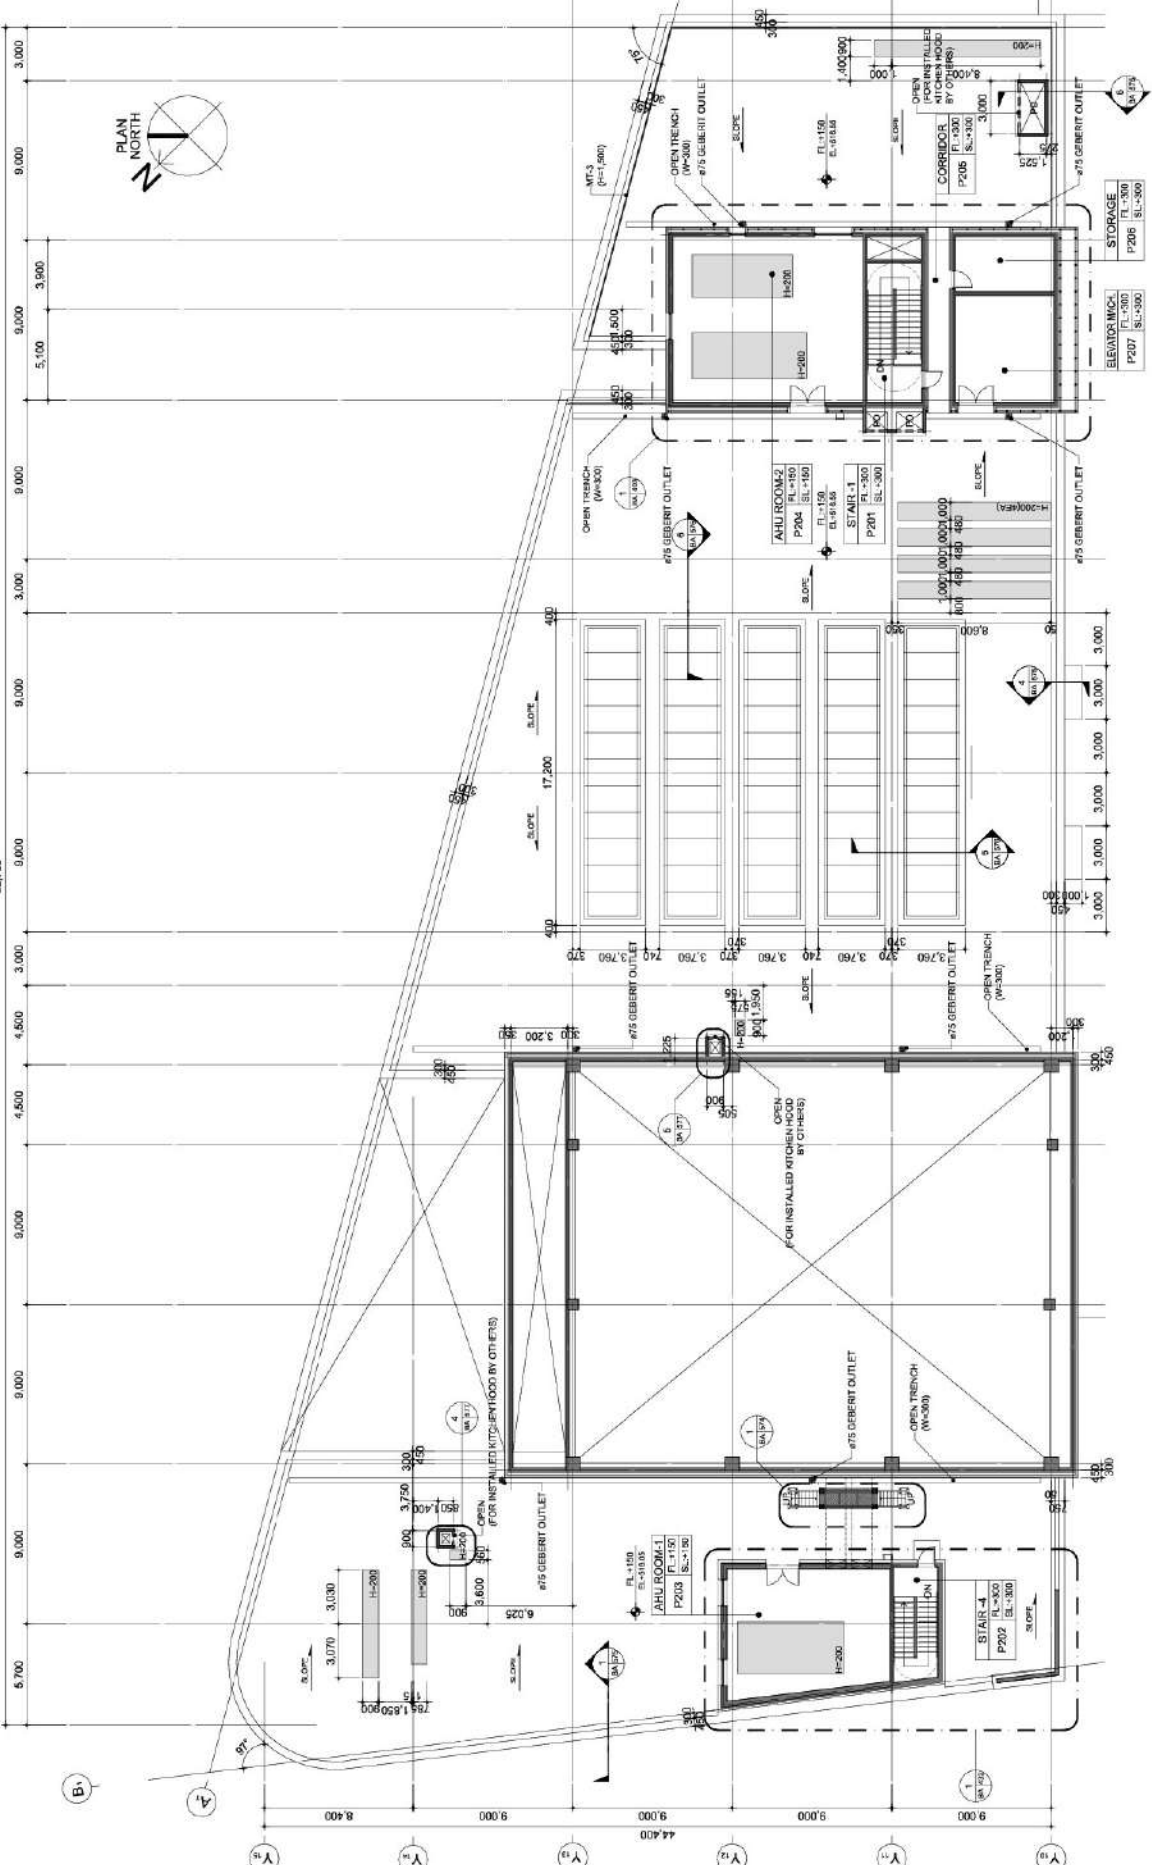

1 ENLARGED FLOOR PLAN-1(2ND)

Scale : 1/150

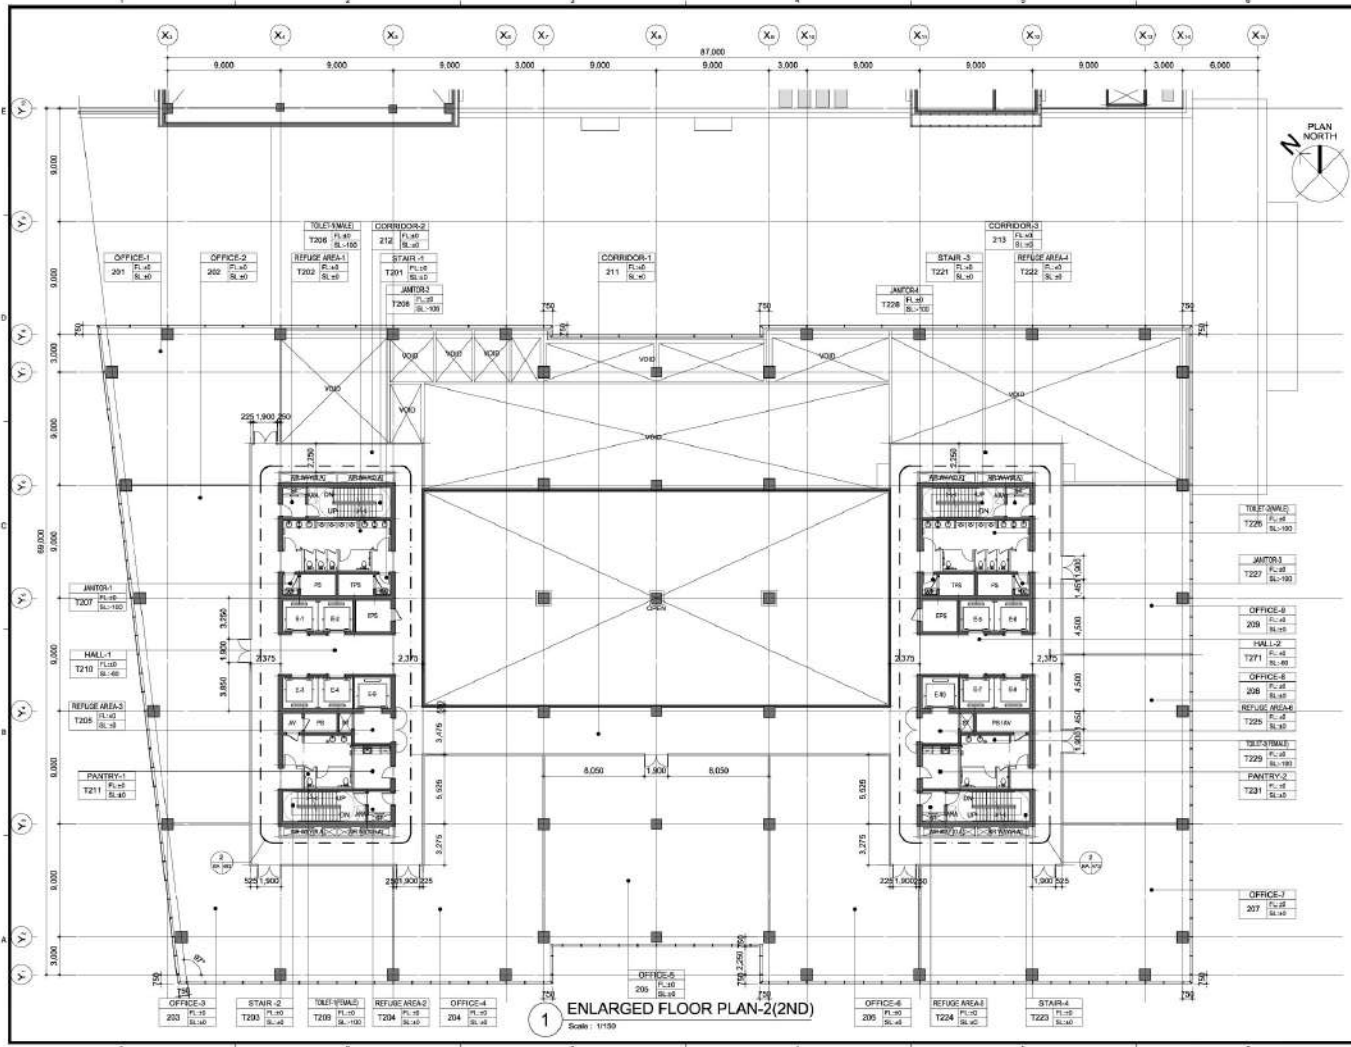

Ministry of Information Technology
Government of Pakistan

TECHNOLOGY PARK
DEVELOPMENT
PROJECT ISLAMABAD

NOTES

NO.	DESCRIPTION	DATE	APPRO.

SUNJIN
ENGINEERING & ARCHITECTURE

DAEWYONG LINTEC CO., LTD.

KU KONKUK
UNIVERSITY

NEC
National Engineering Corporation

ENLARGED FLOOR PLAN-2
(2ND)

DATE	Oct. 2020	DESIGNED BY	Lee, Dongho
SCALE	1/150	CHECKED BY	Lee, Jaeha
DRAWN BY	Lee, Dongho	APPROVED BY	Kang, Jeonung

BA-226

PROJECT NUMBER	420184027	PROJECT NO.	000
----------------	-----------	-------------	-----



TECHNOLOGY PARK
DEVELOPMENT
PROJECT ISLAMABAD

NOTE

[illegible]

SUNJIN
ENGINEERING & ARCHITECTURE


 **DAEYONG UNITED CO., LTD.**



Ministry of Education, Science and Technology of the Republic of Turkey

ENLARGED FLOOR PLAN-1
(3RD)

DATE	Oct. 2020	REMOVED BY	Lee, Dongho
SCALE	1/150	CHUCK NAME	Lee, Jaeho
NAME IN	Lee, Dongho	APPROVED BY	Kang, Jeonung
DRAWING NO.		BA-227	
FILE NAME	PROJECT NO.		000
PROJECT NUMBER			

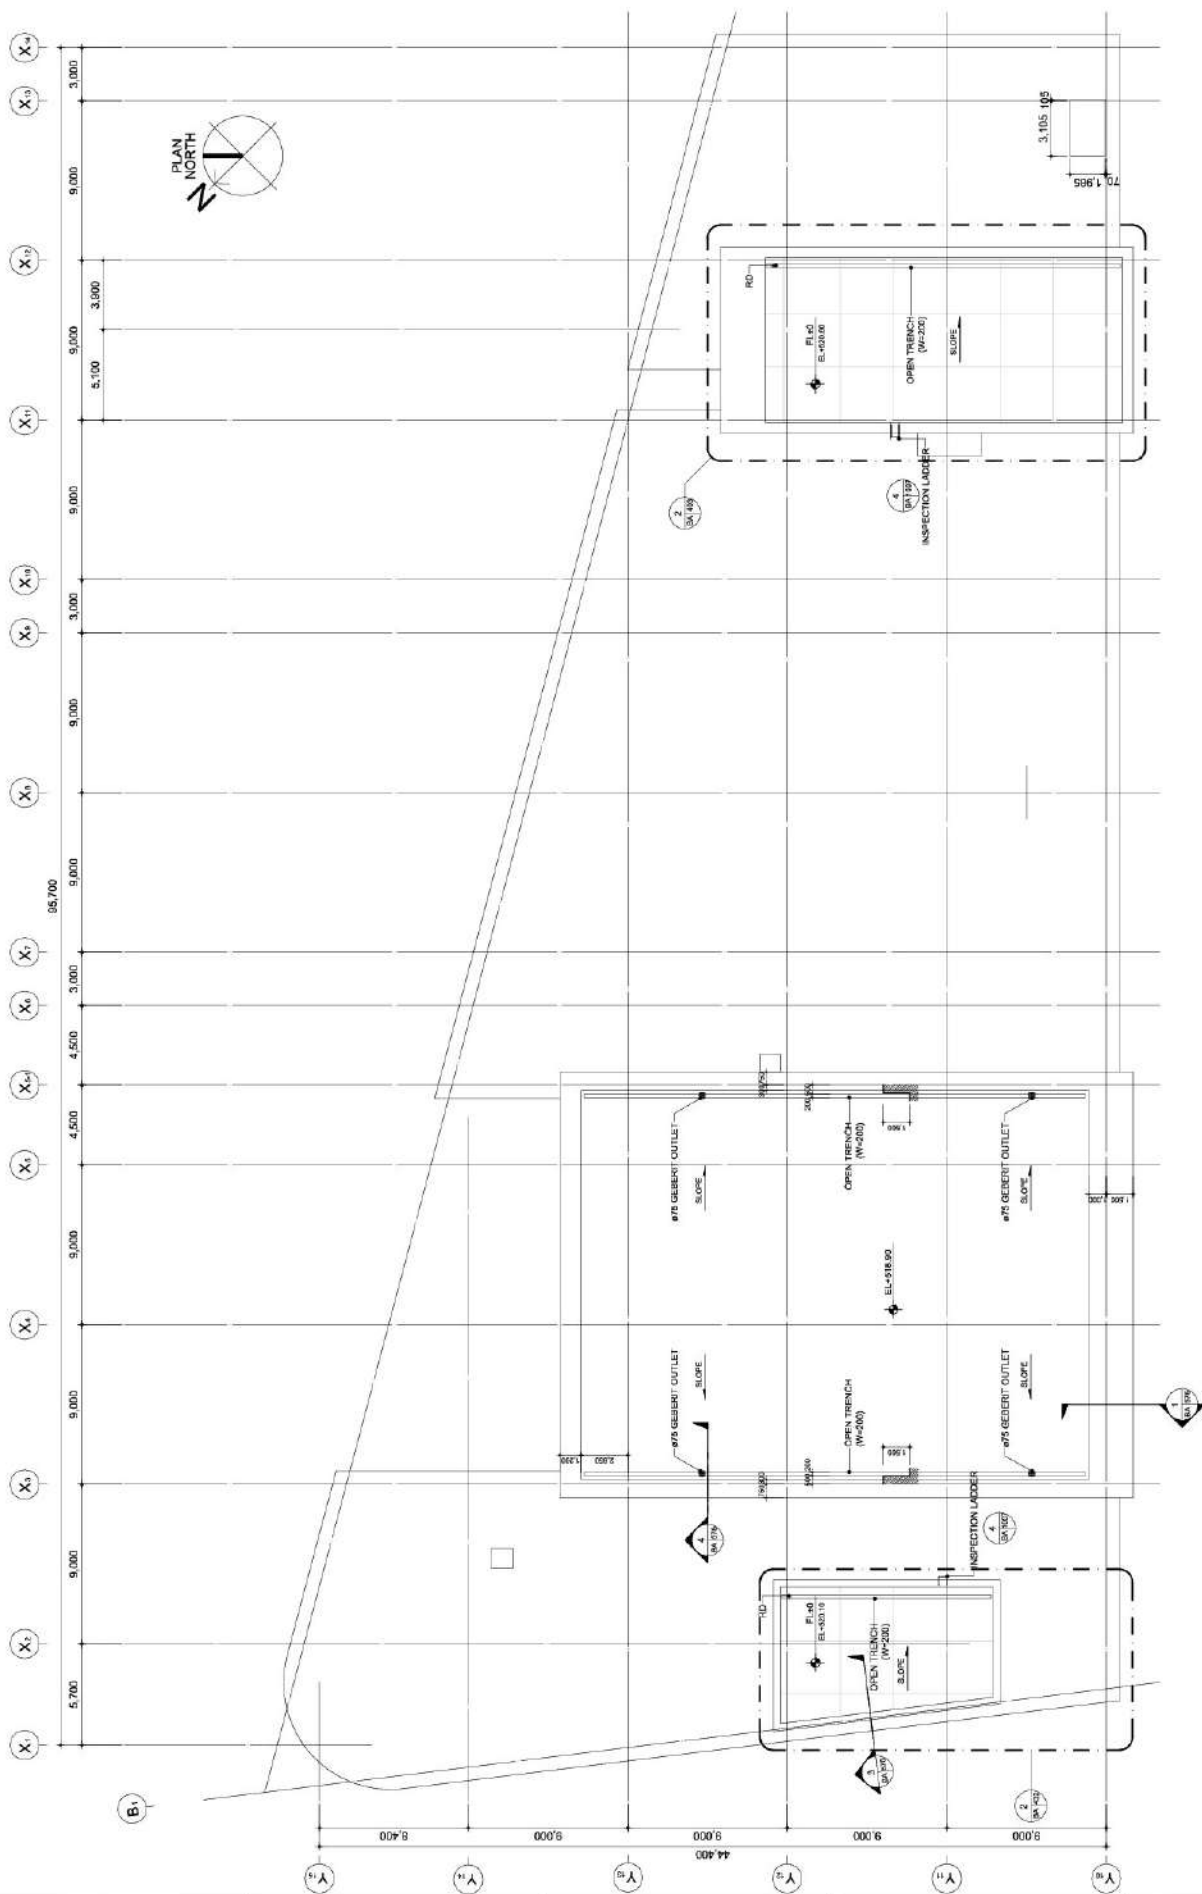

1 ENLARGED FLOOR PLAN-1(3RD)
Scale : 1/150




Ministry of Information Technology
Government of Pakistan

PROJECT TITLE

TECHNOLOGY PARK
DEVELOPMENT
PROJECT ISLAMABAD

NOTE

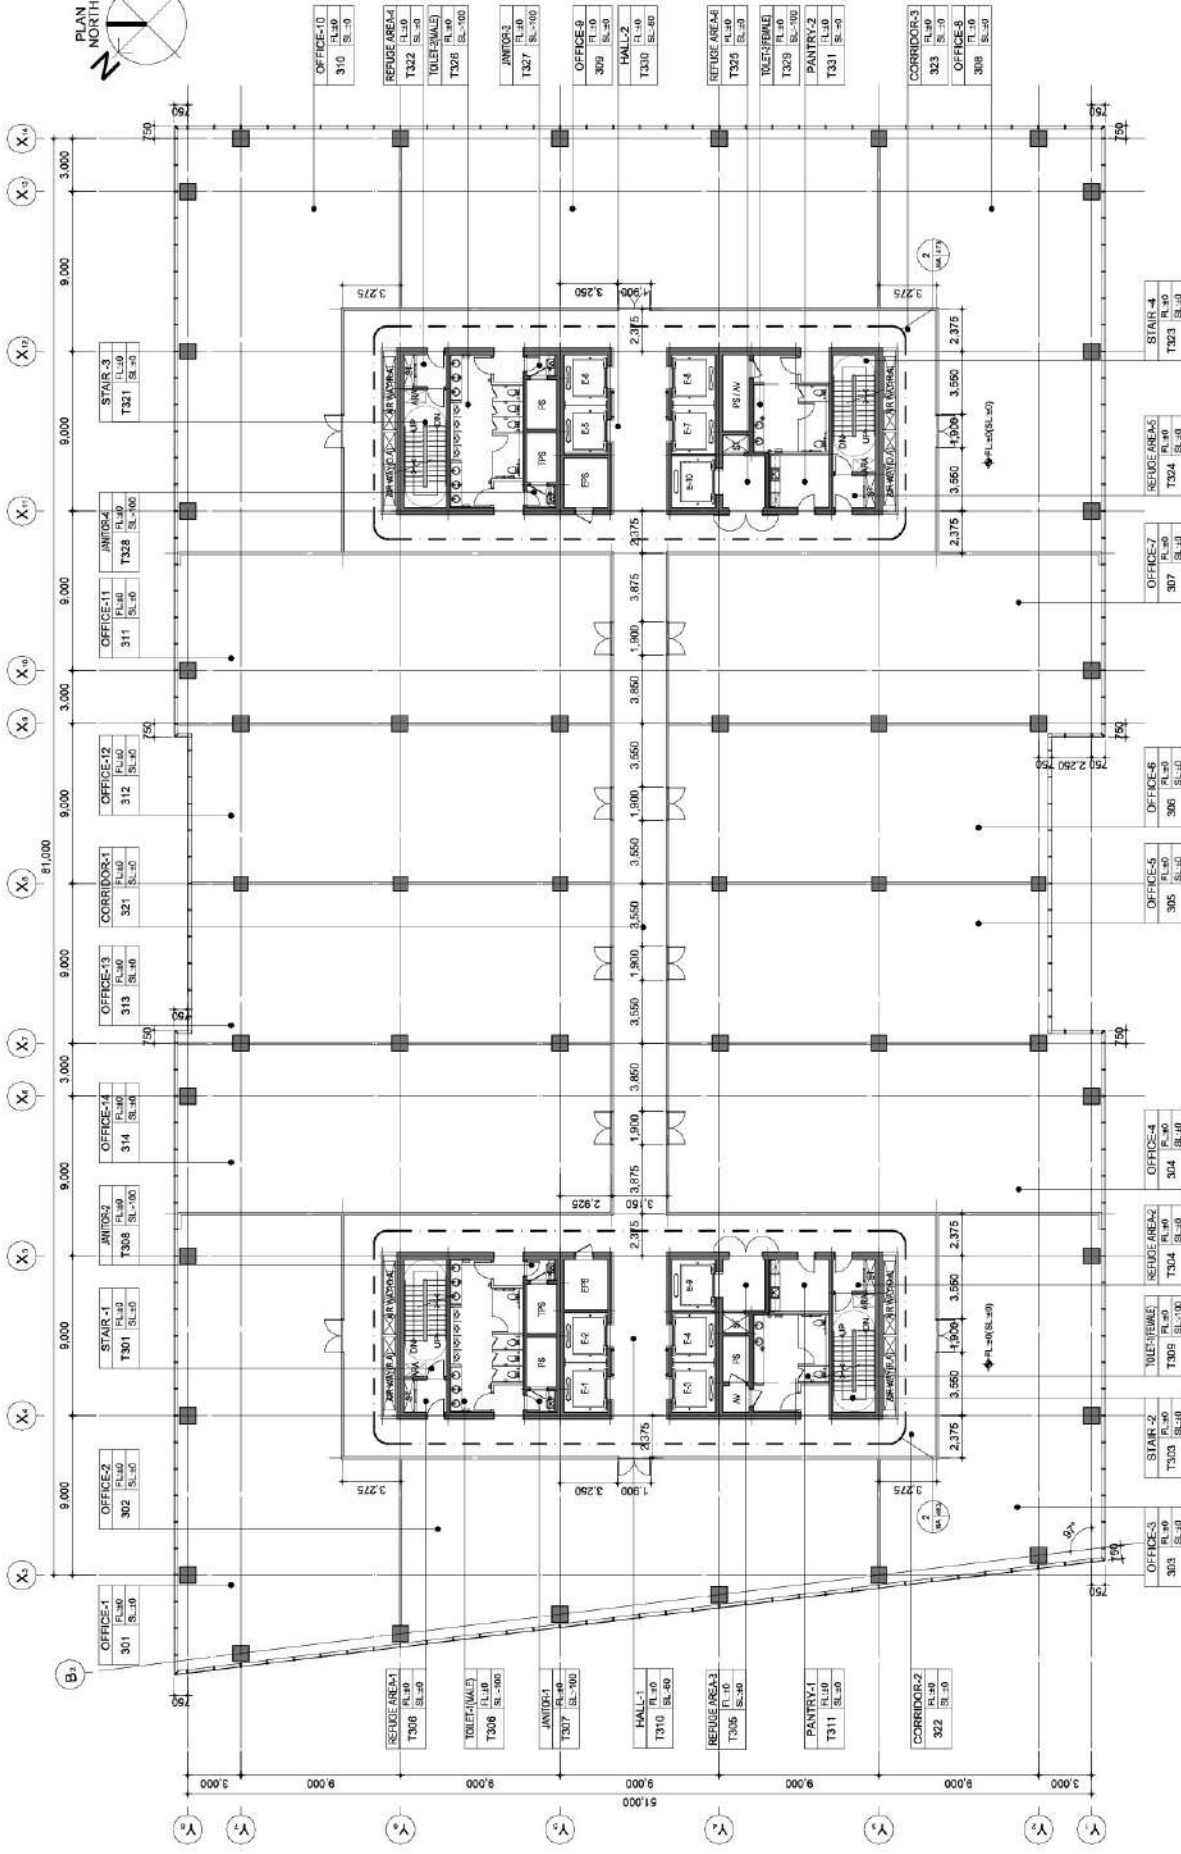

1 ENLARGED FLOOR PLAN-2(3RD)

Scale: 1/150

SUNJIN
ENGINEERING & ARCHITECTURE

DAEWONG UNITED CO. LTD.

KU KONKUK
UNIVERSITY

National Engineering Corporation

ENLARGED FLOOR PLAN-2
(3RD)

DATE: Oct. 2020
DESIGNED BY: Lee, Dongho
CHECKED BY: Lee, Jaeho
SCALE: 1/150
DRAWN BY: Lee, Dongho
APPROVED BY: Kang, Jeonung
DRAWING NO.: BA-228

FILE NAME: PROJECT NUMBER: S20180007



Ministry of Information Technology
Government of Pakistan

PROJECT TITLE

TECHNOLOGY PARK
DEVELOPMENT
PROJECT ISLAMABAD

NOTE

DATE

Oct. 2020

DESIGNED BY

Lee, Dongho

CHECKED BY

Lee, Jaehoo

APPROVED BY

Lee, Dongho

DRAWING NO.

BA-229

PROJECT NUMBER

820186/007

SCALE

1:100

DATE

APPROVED

DATE

APPROVED

DATE

Oct. 2020

DESIGNED BY

Lee, Dongho

CHECKED BY

Lee, Jaehoo

APPROVED BY

Lee, Dongho

DRAWING NO.

BA-229

PROJECT NUMBER

820186/007

SCALE

1:100

DATE

APPROVED

DATE

APPROVED

DATE

Oct. 2020

DESIGNED BY

Lee, Dongho

CHECKED BY

Lee, Jaehoo

APPROVED BY

Lee, Dongho

DRAWING NO.

BA-229

PROJECT NUMBER

820186/007

SCALE

1:100

DATE

APPROVED

DATE

APPROVED

DATE

Oct. 2020

DESIGNED BY

Lee, Dongho

CHECKED BY

Lee, Jaehoo

APPROVED BY

Lee, Dongho

DRAWING NO.

BA-229

PROJECT NUMBER

820186/007

SCALE

1:100

DATE

APPROVED

DATE

APPROVED

DATE

Oct. 2020

DESIGNED BY

Lee, Dongho

CHECKED BY

Lee, Jaehoo

APPROVED BY

Lee, Dongho

DRAWING NO.

BA-229

PROJECT NUMBER

820186/007

SCALE

1:100

DATE

APPROVED

DATE

APPROVED

DATE

Oct. 2020

DESIGNED BY

Lee, Dongho

CHECKED BY

Lee, Jaehoo

APPROVED BY

Lee, Dongho

DRAWING NO.

BA-229

PROJECT NUMBER

820186/007

SCALE

1:100

DATE

APPROVED

DATE

APPROVED

DATE


 


Ministry of Information Technology
Government of Pakistan

PROJECT TITLE

TECHNOLOGY PARK
DEVELOPMENT
PROJECT ISLAMABAD

NOTE

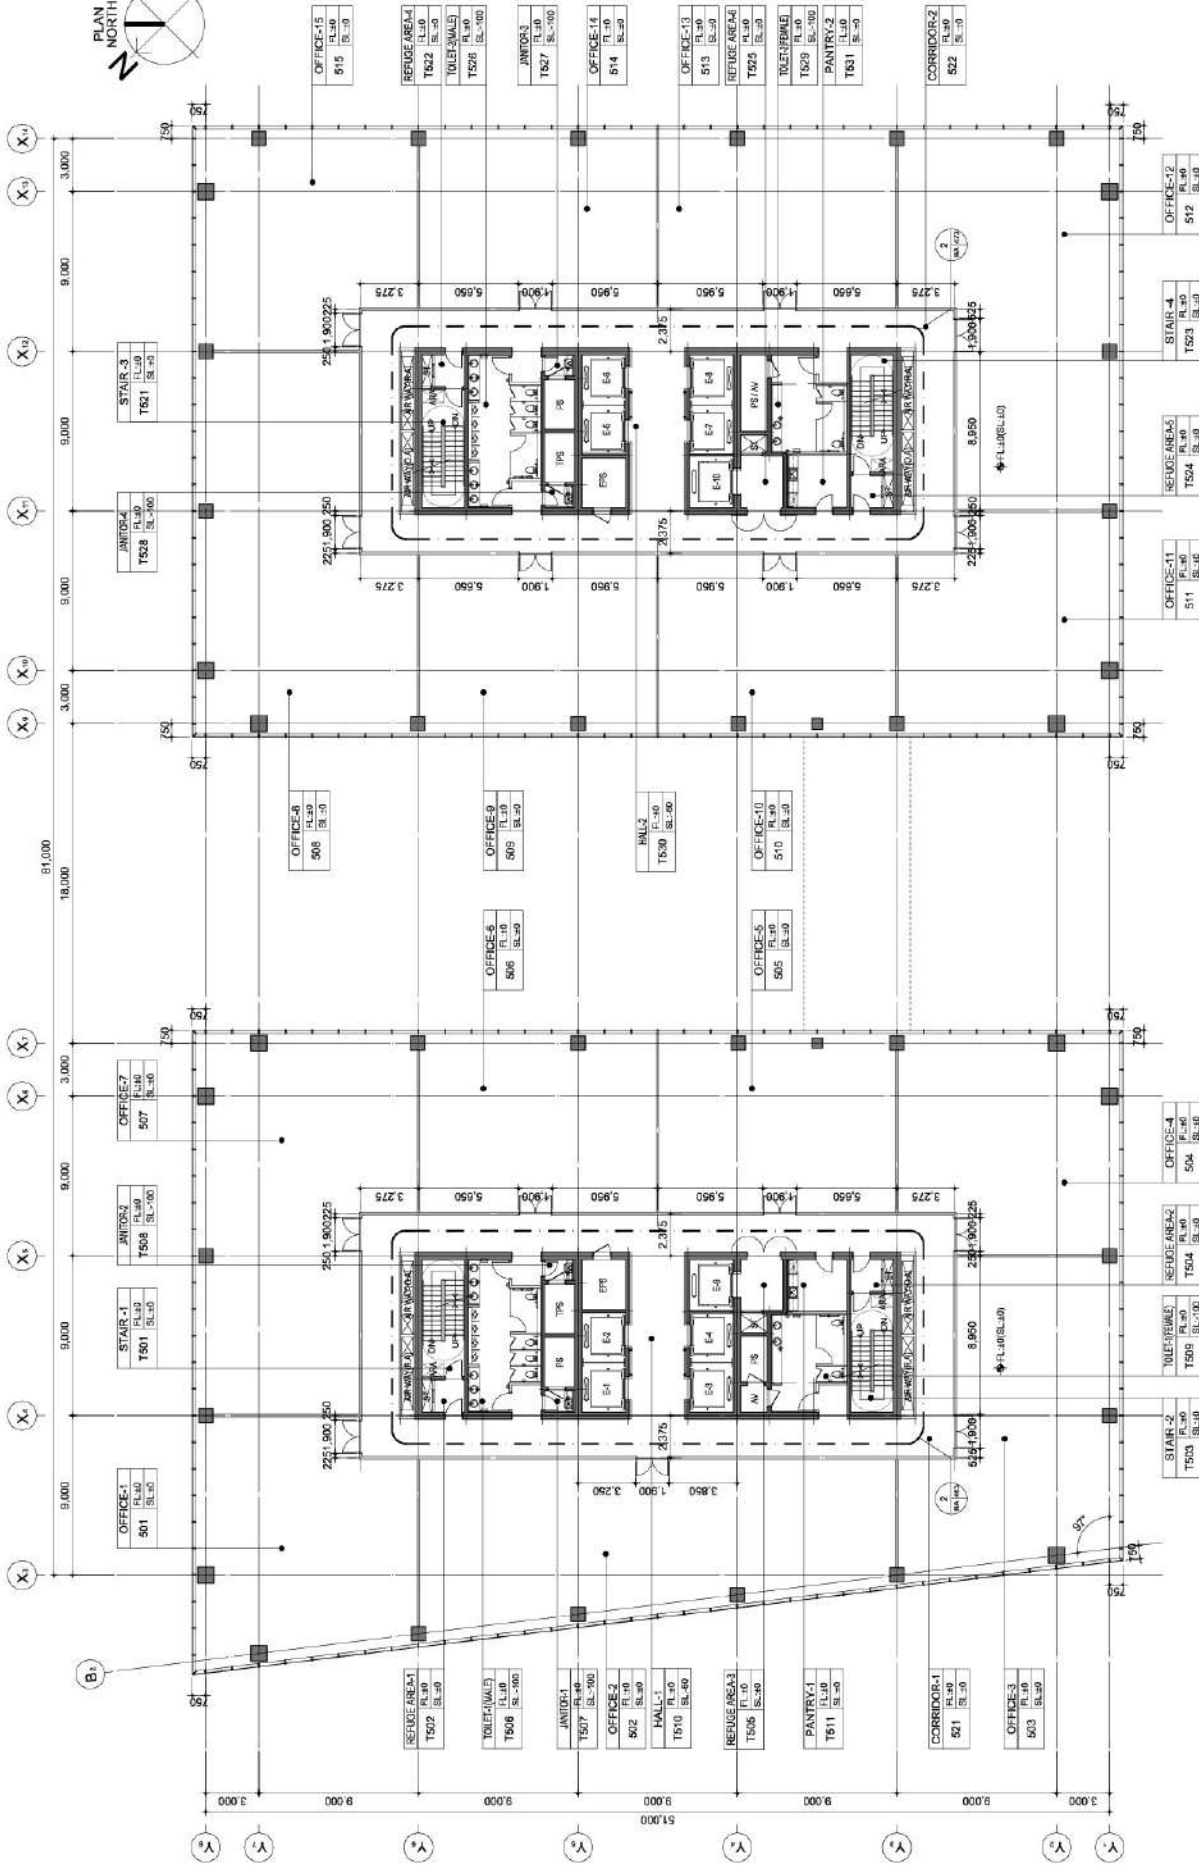

1 ENLARGED FLOOR PLAN(5TH)

Scale: 1:150

SUNJIN
ENGINEERING & ARCHITECTURE

DAEWON UNITED CO. LTD.

KU KONKUK
UNIVERSITY

National Engineering Corporation

ENLARGED FLOOR PLAN
(5TH)

DATE: Oct. 2020
DRAWN BY: Lee, Dongho
CHECKED BY: Lee, Jaeho
SCALE: 1/150
PROJECT NO: 2019-007

APPROVED BY: Kang, Jeonung
DRAWING NO: BA-230

FILE NAME: 5TH FLOOR
PROJECT NUMBER: 2019-007

000



Ministry of Information Technology
Government of Pakistan

TECHNOLOGY PARK
DEVELOPMENT
PROJECT ISLAMABAD

NOTE



OFFICE-13
FL-10
SL-30

REFUGEE AREA-4
FL-10
SL-30

TOILET-2
FL-10
SL-30

JANITOR-3
FL-10
SL-30

OFFICE-12
FL-10
SL-30

OFFICE-11
FL-10
SL-30

REFUGEE AREA-3
FL-10
SL-30

TOILET-1
FL-10
SL-30

JANITOR-2
FL-10
SL-30

PANTRY-2
FL-10
SL-30

CORRIDOR-2
FL-10
SL-30

OFFICE-10
FL-10
SL-30

STAR-4
FL-10
SL-30

REFUGEE AREA-2
FL-10
SL-30

TOILET-3
FL-10
SL-30

JANITOR-4
FL-10
SL-30

OFFICE-9
FL-10
SL-30

STAR-3
FL-10
SL-30

REFUGEE AREA-1
FL-10
SL-30

TOILET-4
FL-10
SL-30

JANITOR-1
FL-10
SL-30

OFFICE-8
FL-10
SL-30

STAR-2
FL-10
SL-30

REFUGEE AREA-5
FL-10
SL-30

TOILET-5
FL-10
SL-30

JANITOR-5
FL-10
SL-30

OFFICE-7
FL-10
SL-30

STAR-1
FL-10
SL-30

REFUGEE AREA-6
FL-10
SL-30

TOILET-6
FL-10
SL-30

JANITOR-6
FL-10
SL-30

OFFICE-6
FL-10
SL-30

STAR-5
FL-10
SL-30

REFUGEE AREA-7
FL-10
SL-30

TOILET-7
FL-10
SL-30

JANITOR-7
FL-10
SL-30

OFFICE-5
FL-10
SL-30

STAR-6
FL-10
SL-30

REFUGEE AREA-8
FL-10
SL-30

TOILET-8
FL-10
SL-30

JANITOR-8
FL-10
SL-30

OFFICE-4
FL-10
SL-30

STAR-7
FL-10
SL-30

REFUGEE AREA-9
FL-10
SL-30

TOILET-9
FL-10
SL-30

JANITOR-9
FL-10
SL-30

OFFICE-3
FL-10
SL-30

STAR-8
FL-10
SL-30

REFUGEE AREA-10
FL-10
SL-30

TOILET-10
FL-10
SL-30

JANITOR-10
FL-10
SL-30

OFFICE-2
FL-10
SL-30

STAR-9
FL-10
SL-30

REFUGEE AREA-11
FL-10
SL-30

TOILET-11
FL-10
SL-30

JANITOR-11
FL-10
SL-30

OFFICE-1
FL-10
SL-30

STAR-10
FL-10
SL-30

REFUGEE AREA-12
FL-10
SL-30

TOILET-12
FL-10
SL-30

JANITOR-12
FL-10
SL-30

OFFICE-0
FL-10
SL-30

STAR-11
FL-10
SL-30

REFUGEE AREA-13
FL-10
SL-30

TOILET-13
FL-10
SL-30

JANITOR-13
FL-10
SL-30

OFFICE-14
FL-10
SL-30

STAR-12
FL-10
SL-30

REFUGEE AREA-14
FL-10
SL-30

TOILET-14
FL-10
SL-30

JANITOR-14
FL-10
SL-30

OFFICE-15
FL-10
SL-30

STAR-13
FL-10
SL-30

REFUGEE AREA-15
FL-10
SL-30

TOILET-15
FL-10
SL-30

JANITOR-15
FL-10
SL-30

OFFICE-16
FL-10
SL-30

STAR-14
FL-10
SL-30

REFUGEE AREA-16
FL-10
SL-30

TOILET-16
FL-10
SL-30

JANITOR-16
FL-10
SL-30

OFFICE-17
FL-10
SL-30

STAR-15
FL-10
SL-30

REFUGEE AREA-17
FL-10
SL-30

TOILET-17
FL-10
SL-30

JANITOR-17
FL-10
SL-30

OFFICE-18
FL-10
SL-30

STAR-16
FL-10
SL-30

REFUGEE AREA-18
FL-10
SL-30

TOILET-18
FL-10
SL-30

JANITOR-18
FL-10
SL-30

OFFICE-19
FL-10
SL-30

STAR-17
FL-10
SL-30

REFUGEE AREA-19
FL-10
SL-30

TOILET-19
FL-10
SL-30

JANITOR-19
FL-10
SL-30

OFFICE-20
FL-10
SL-30

STAR-18
FL-10
SL-30

REFUGEE AREA-20
FL-10
SL-30

TOILET-20
FL-10
SL-30

JANITOR-20
FL-10
SL-30

OFFICE-21
FL-10
SL-30

STAR-19
FL-10
SL-30

REFUGEE AREA-21
FL-10
SL-30

TOILET-21
FL-10
SL-30

JANITOR-21
FL-10
SL-30

OFFICE-22
FL-10
SL-30

STAR-20
FL-10
SL-30

REFUGEE AREA-22
FL-10
SL-30

TOILET-22
FL-10
SL-30

JANITOR-22
FL-10
SL-30

OFFICE-23
FL-10
SL-30

STAR-21
FL-10
SL-30

REFUGEE AREA-23
FL-10
SL-30

TOILET-23
FL-10
SL-30

JANITOR-23
FL-10
SL-30

OFFICE-24
FL-10
SL-30

STAR-22
FL-10
SL-30

REFUGEE AREA-24
FL-10
SL-30

TOILET-24
FL-10
SL-30

JANITOR-24
FL-10
SL-30

OFFICE-25
FL-10
SL-30

STAR-23
FL-10
SL-30

REFUGEE AREA-25
FL-10
SL-30

TOILET-25
FL-10
SL-30

JANITOR-25
FL-10
SL-30

OFFICE-26
FL-10
SL-30

STAR-24
FL-10
SL-30

REFUGEE AREA-26
FL-10
SL-30

TOILET-26
FL-10
SL-30

JANITOR-26
FL-10
SL-30

OFFICE-27
FL-10
SL-30

STAR-25
FL-10
SL-30

REFUGEE AREA-27
FL-10
SL-30

TOILET-27
FL-10
SL-30

JANITOR-27
FL-10
SL-30

OFFICE-28
FL-10
SL-30

STAR-26
FL-10
SL-30

REFUGEE AREA-28
FL-10
SL-30

TOILET-28
FL-10
SL-30

JANITOR-28
FL-10
SL-30

OFFICE-29
FL-10
SL-30

STAR-27
FL-10
SL-30

REFUGEE AREA-29
FL-10
SL-30

TOILET-29
FL-10
SL-30

JANITOR-29
FL-10
SL-30

OFFICE-30
FL-10
SL-30

STAR-28
FL-10
SL-30

REFUGEE AREA-30
FL-10
SL-30

TOILET-30
FL-10
SL-30

JANITOR-30
FL-10
SL-30

OFFICE-31
FL-10
SL-30

STAR-29
FL-10
SL-30

REFUGEE AREA-31
FL-10
SL-30

TOILET-31
FL-10
SL-30

JANITOR-31
FL-10
SL-30

OFFICE-32
FL-10
SL-30

STAR-30
FL-10
SL-30

REFUGEE AREA-32
FL-10
SL-30

TOILET-32
FL-10
SL-30

JANITOR-32
FL-10
SL-30

OFFICE-33
FL-10
SL-30

STAR-31
FL-10
SL-30

REFUGEE AREA-33
FL-10
SL-30

TOILET-33
FL-10
SL-30

JANITOR-33
FL-10
SL-30

OFFICE-34
FL-10
SL-30

STAR-32
FL-10
SL-30

REFUGEE AREA-34
FL-10
SL-30

TOILET-34
FL-10
SL-30

JANITOR-34
FL-10
SL-30

OFFICE-35
FL-10
SL-30

STAR-33
FL-10
SL-30

REFUGEE AREA-35
FL-10
SL-30

TOILET-35
FL-10
SL-30

JANITOR-35
FL-10
SL-30

OFFICE-36
FL-10
SL-30

STAR-34
FL-10
SL-30

REFUGEE AREA-36
FL-10
SL-30

TOILET-36
FL-10
SL-30

JANITOR-36
FL-10
SL-30

OFFICE-37
FL-10
SL-30

STAR-35
FL-10
SL-30

REFUGEE AREA-37
FL-10
SL-30

TOILET-37
FL-10
SL-30

JANITOR-37
FL-10
SL-30

OFFICE-38
FL-10
SL-30

STAR-36
FL-10
SL-30

REFUGEE AREA-38
FL-10
SL-30

TOILET-38
FL-10
SL-30

JANITOR-38
FL-10
SL-30

OFFICE-39
FL-10
SL-30

STAR-37
FL-10
SL-30

REFUGEE AREA-39
FL-10
SL-30

TOILET-39
FL-10
SL-30

JANITOR-39
FL-10
SL-30

OFFICE-40
FL-10
SL-30

STAR-38
FL-10
SL-30

REFUGEE AREA-40
FL-10
SL-30

TOILET-40
FL-10
SL-30

JANITOR-40
FL-10
SL-30

OFFICE-41
FL-10
SL-30

STAR-39
FL-10
SL-30

REFUGEE AREA-41
FL-10
SL-30

TOILET-41
FL-10
SL-30

JANITOR-41
FL-10
SL-30

OFFICE-42
FL-10
SL-30

STAR-40
FL-10
SL-30

REFUGEE AREA-42
FL-10
SL-30

TOILET-42
FL-10
SL-30

JANITOR-42
FL-10
SL-30

OFFICE-43
FL-10
SL-30

STAR-41
FL-10
SL-30

REFUGEE AREA-43
FL-10
SL-30

TOILET-43
FL-10
SL-30

JANITOR-43
FL-10
SL-30

OFFICE-44
FL-10
SL-30

STAR-42
FL-10
SL-30

REFUGEE AREA-44
FL-10
SL-30

TOILET-44
FL-10
SL-30

JANITOR-44
FL-10
SL-30

OFFICE-45
FL-10
SL-30

STAR-43
FL-10
SL-30

REFUGEE AREA-45
FL-10
SL-30

TOILET-45
FL-10
SL-30

JANITOR-45
FL-10
SL-30

OFFICE-46
FL-10
SL-30

STAR-44
FL-10
SL-30

REFUGEE AREA-46
FL-10
SL-30

TOILET-46
FL-10
SL-30

JANITOR-46
FL-10
SL-30

OFFICE-47
FL-10
SL-30

STAR-45
FL-10
SL-30


REFUGEE AREA-47
FL-10
SL-30



Ministry of Information Technology
Government of Pakistan

TECHNOLOGY PARK
DEVELOPMENT
PROJECT ISLAMABAD

NOTE

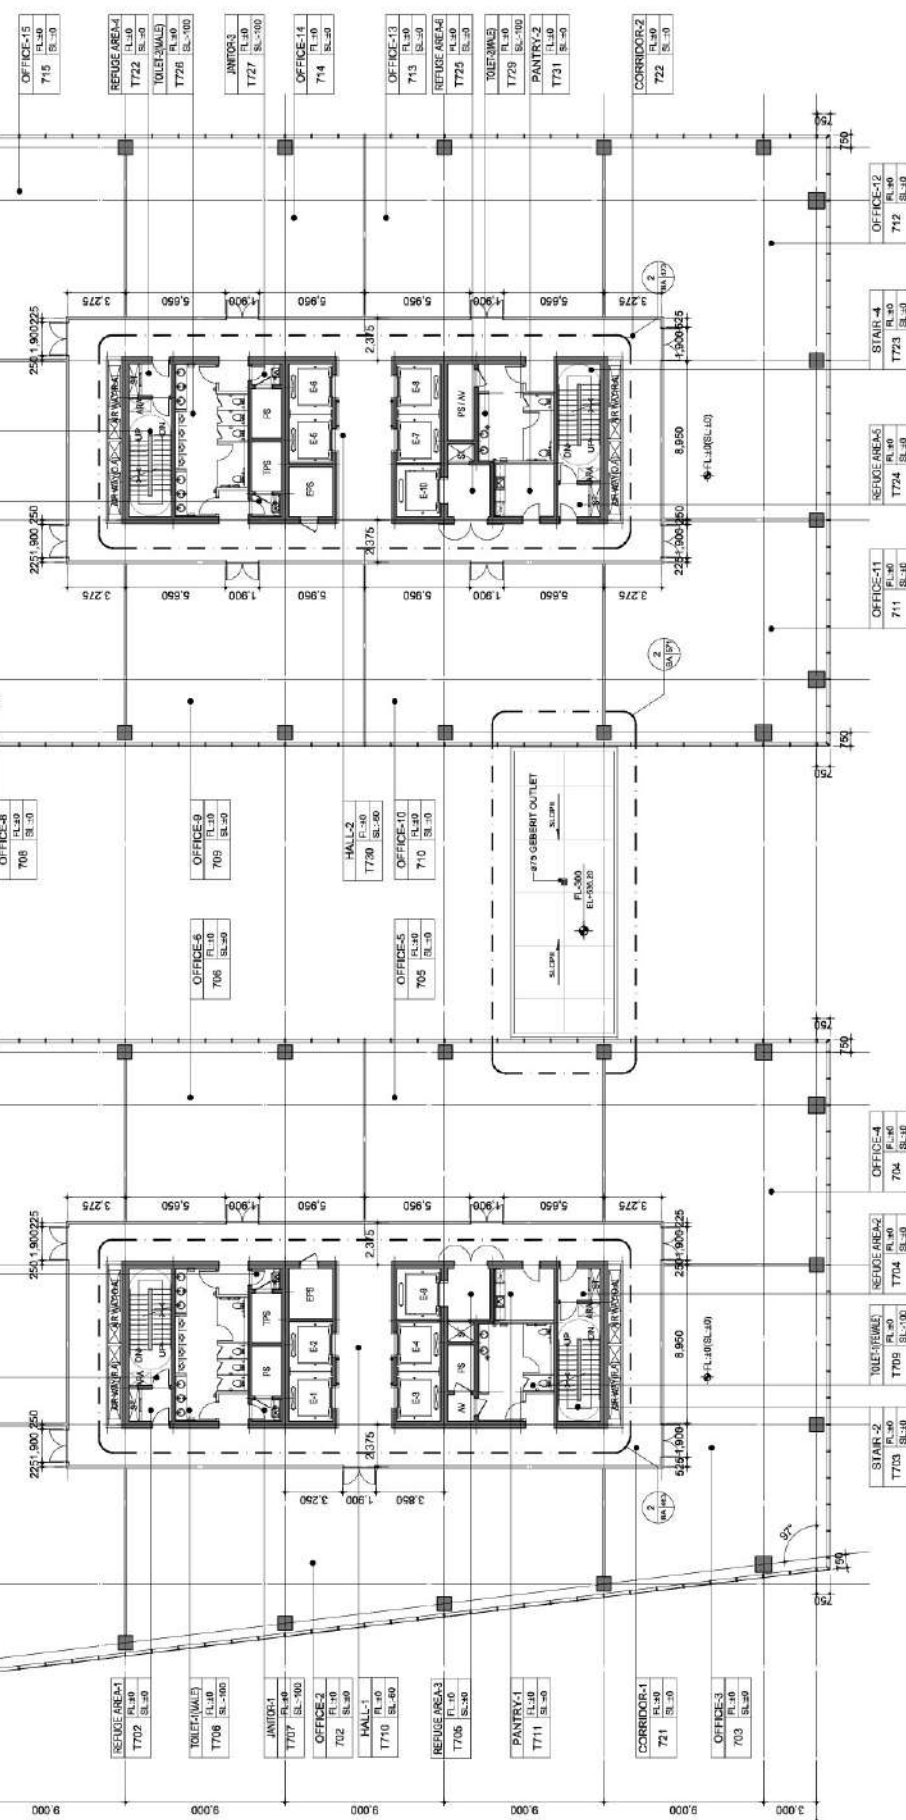

1 ENLARGED FLOOR PLAN(7TH)

Scale: 1:1150

SUNJIN
ENGINEERING & ARCHITECTURE

DAEWONG UNITED CO., LTD.

KU KONKUK
UNIVERSITY

National Engineering Corporation

ENLARGED FLOOR PLAN
(7TH)

DATE: Oct. 2020
DESIGNED BY: Lee, Dongho
CHECKED BY: Lee, Jaeho
SCALE: 1/1500
DRAWN BY: Lee, Dongho
APPROVED BY: Kang, Jeonung
DRAWING NO.: BA-232


FILE NAME: 82018a007
PROJECT NUMBER: 000



Ministry of Information Technology
Government of Pakistan

TECHNOLOGY PARK
DEVELOPMENT
PROJECT ISLAMABAD

NOTE

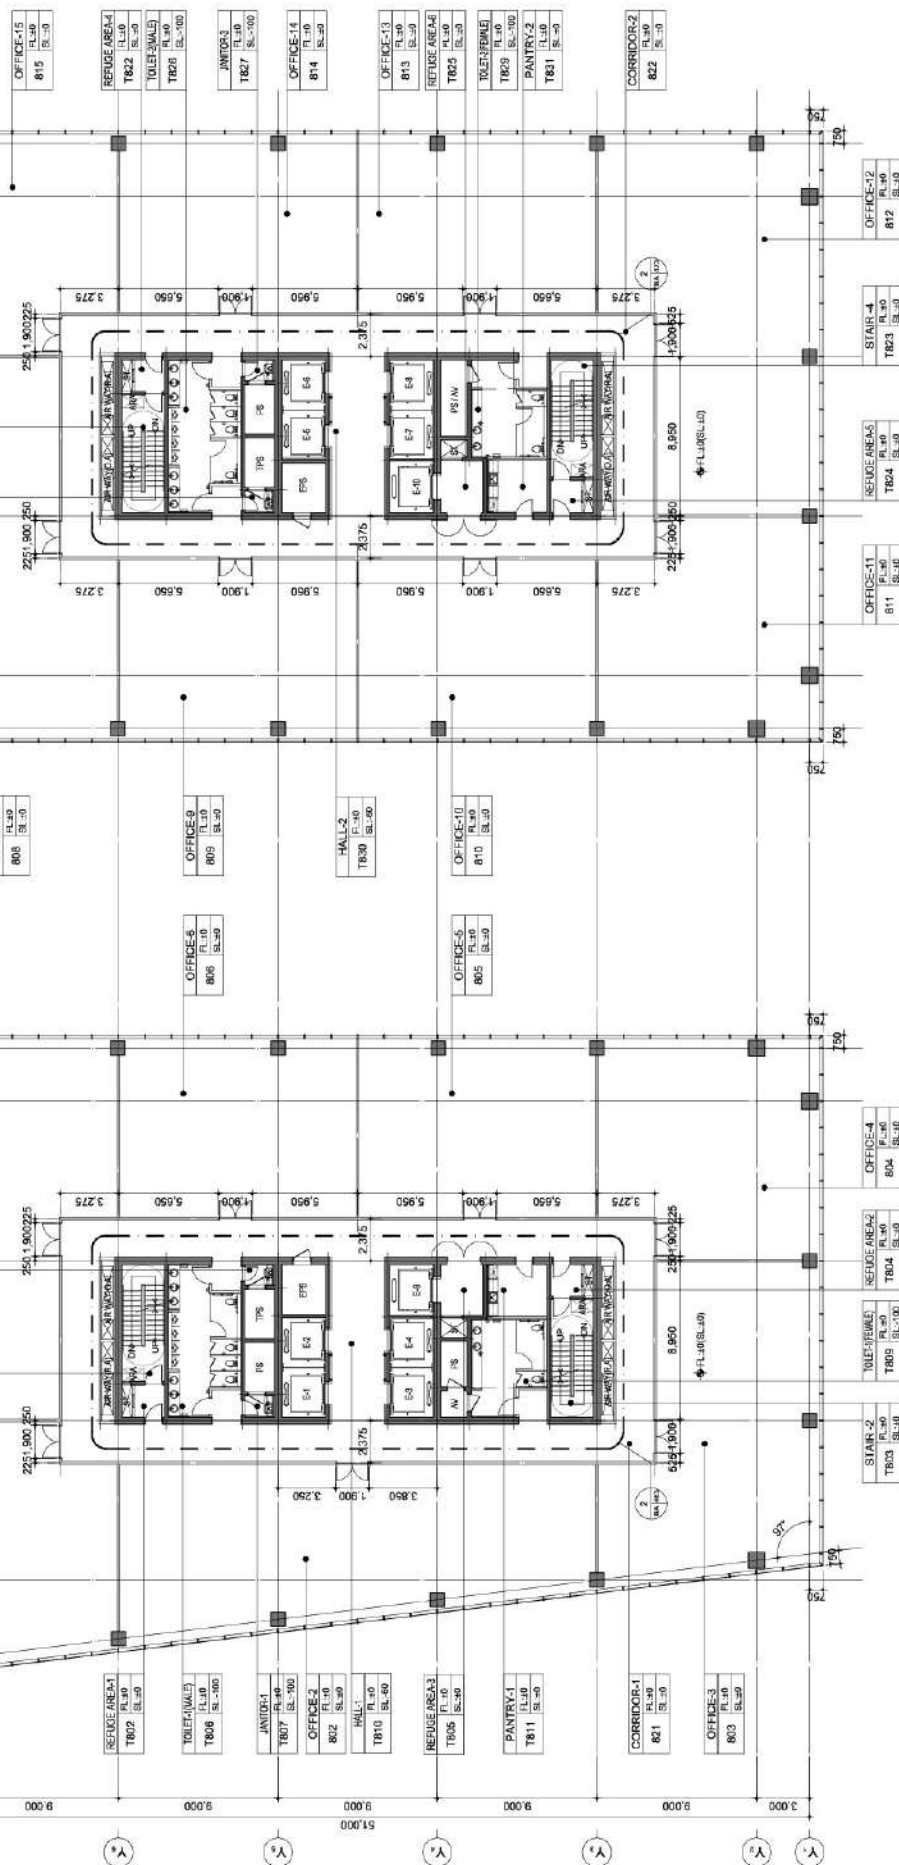

1 ENLARGED FLOOR PLAN(8TH)

Scale: 1:1150

SUNJIN
ENGINEERING & ARCHITECTURE

DAEWONG UNITED CO. LTD.

KU KONKUK
UNIVERSITY

National Engineering Corporation

ENLARGED FLOOR PLAN
(8TH)

DATE	Oct. 2020	DESIGNED BY	Lee Dongho
SCALE	1/150	CHECKED BY	Lee Jaehyo
DRAWN BY	Lee Dongho	APPROVED BY	Kang Jeonung
DRAWING NO.	BA-233		
FILE NAME	PROJECT NUMBER	000	
	820186007		


 


Ministry of Information Technology
Government of Pakistan

PROJECT TITLE

TECHNOLOGY PARK
DEVELOPMENT
PROJECT ISLAMABAD

NOTE

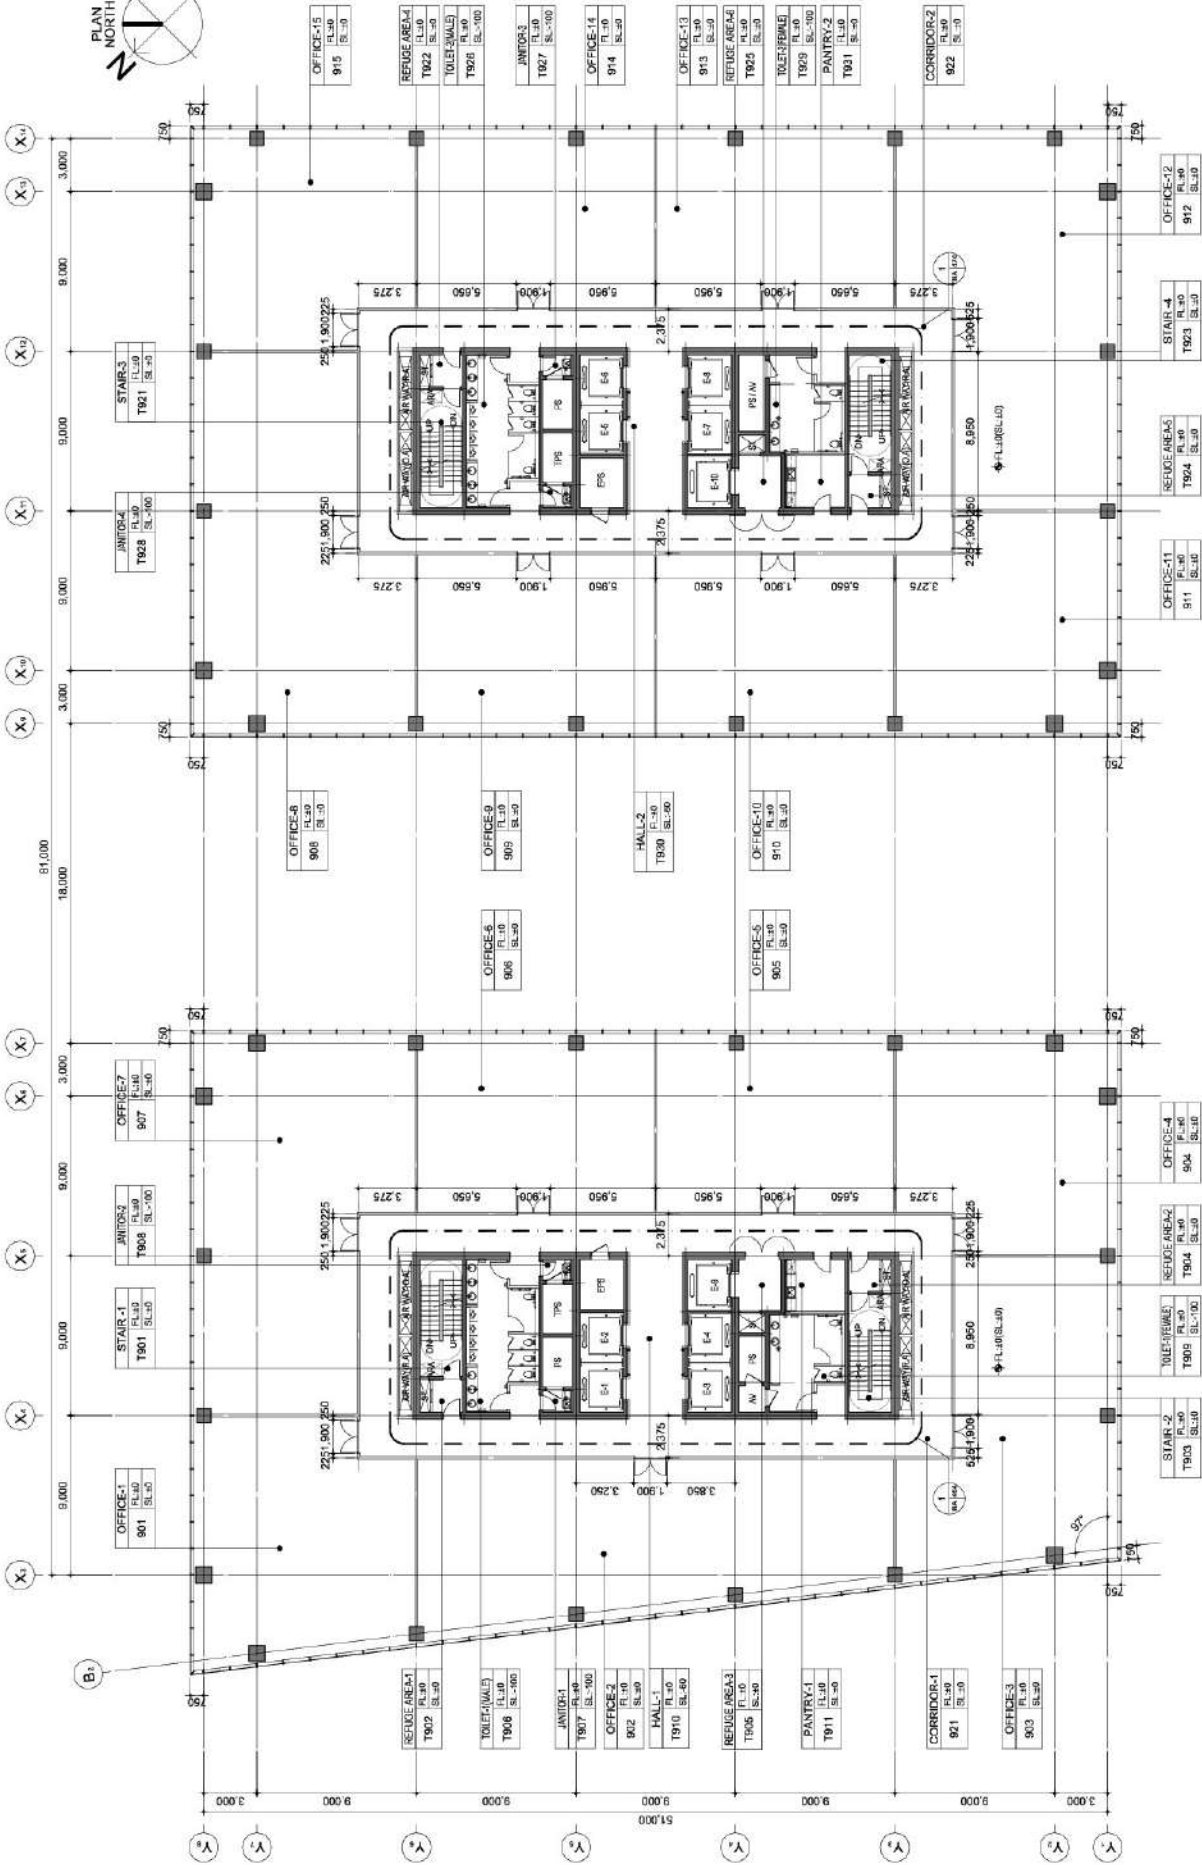

1 ENLARGED FLOOR PLAN(9TH)

Scale: 1:1150

SUNJIN
ENGINEERING & ARCHITECTURE

DAEWONG UNITED CO. LTD.

KU KONKUK
UNIVERSITY

National Engineering Corporation

ENLARGED FLOOR PLAN
(9TH)

DATE: Oct. 2020
DRAWN BY: Lee, Dongho
CHECKED BY: Lee, Jaeho
SCALE: 1/1150
PROJECT NO: 2019007

APPROVED BY: Kang, Jeonung
DRAWING NO: BA-234

FILE NAME: 9TH FLOOR
PROJECT NUMBER: 2019007

000



TECHNOLOGY PARK
DEVELOPMENT
PROJECT ISLAMABAD


NOTE
PAD H 203

[illegible]

National Engineering Corporation

ENLARGED FLOOR PLAN
(ROOF)

DATE	Oct. 2020	REMOVED BY	Lee, Dongho
SCALE	1/150	CHG-2187	Lee, Jaeho
PREP BY	Lee, Dongho	APPROVED BY	Kang, Jeonung
BA-235 DRAWING NO.			
FILE NAME	PROJECT NUMBER		
	8/2019/007		

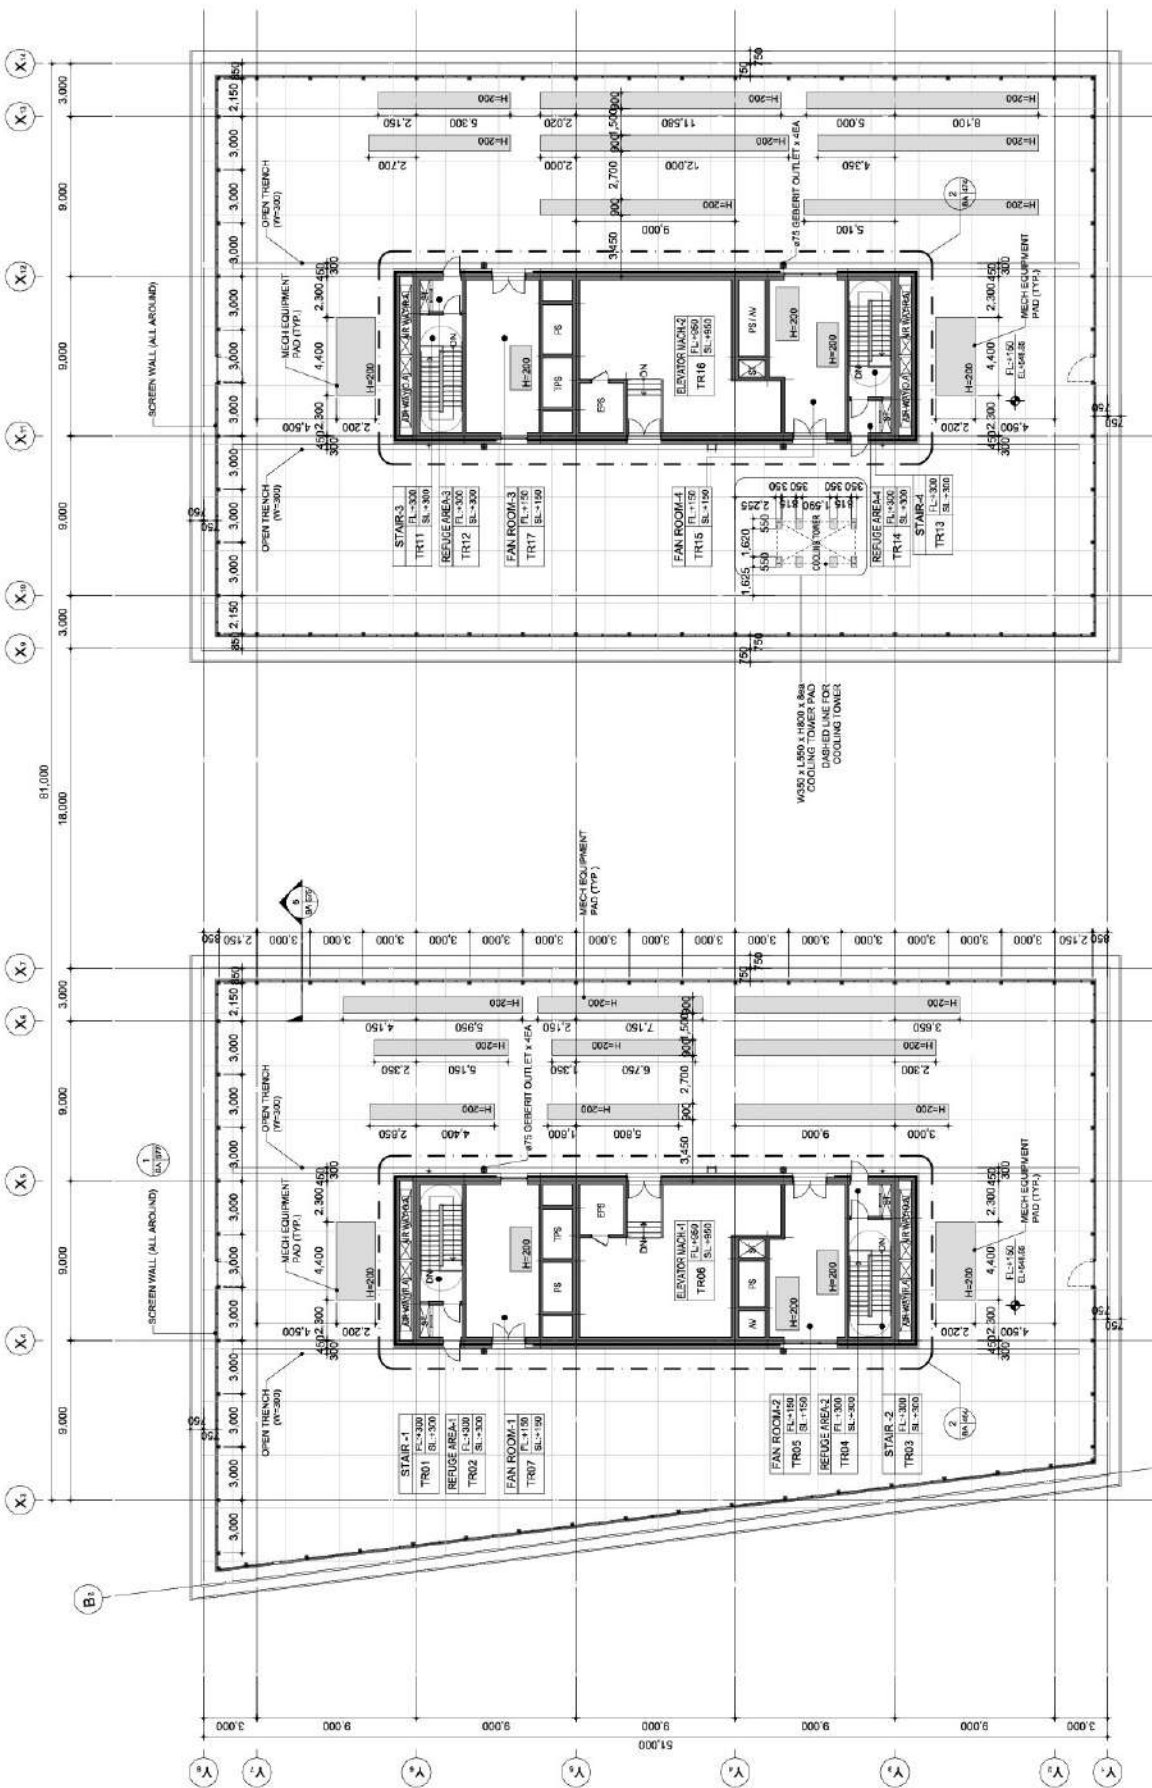

1
ENLARGED FLOOR PLAN(ROOF)

Scale: 1/150



Ministry of Information Technology
Government of Pakistan

PROJECT TITLE

TECHNOLOGY PARK
DEVELOPMENT
PROJECT ISLAMABAD

NOTE

NO.	REVISION	DATE	APPV.

SUNJIN
ENGINEERING & ARCHITECTURE

DAEWON UNITED CO. LTD.

KU KONKUK
UNIVERSITY



National Engineering Corporation

ENLARGED FLOOR PLAN
(ROOF TOP)

DATE

Oct. 2020

DESIGNED BY

Lee Dongho

CHECKED BY

Lee, Jaeho

APPROVED BY

Lee Dongho

DRAWING NO.


BA-236

FILE NAME

PROJECT NUMBER

S20180007

000

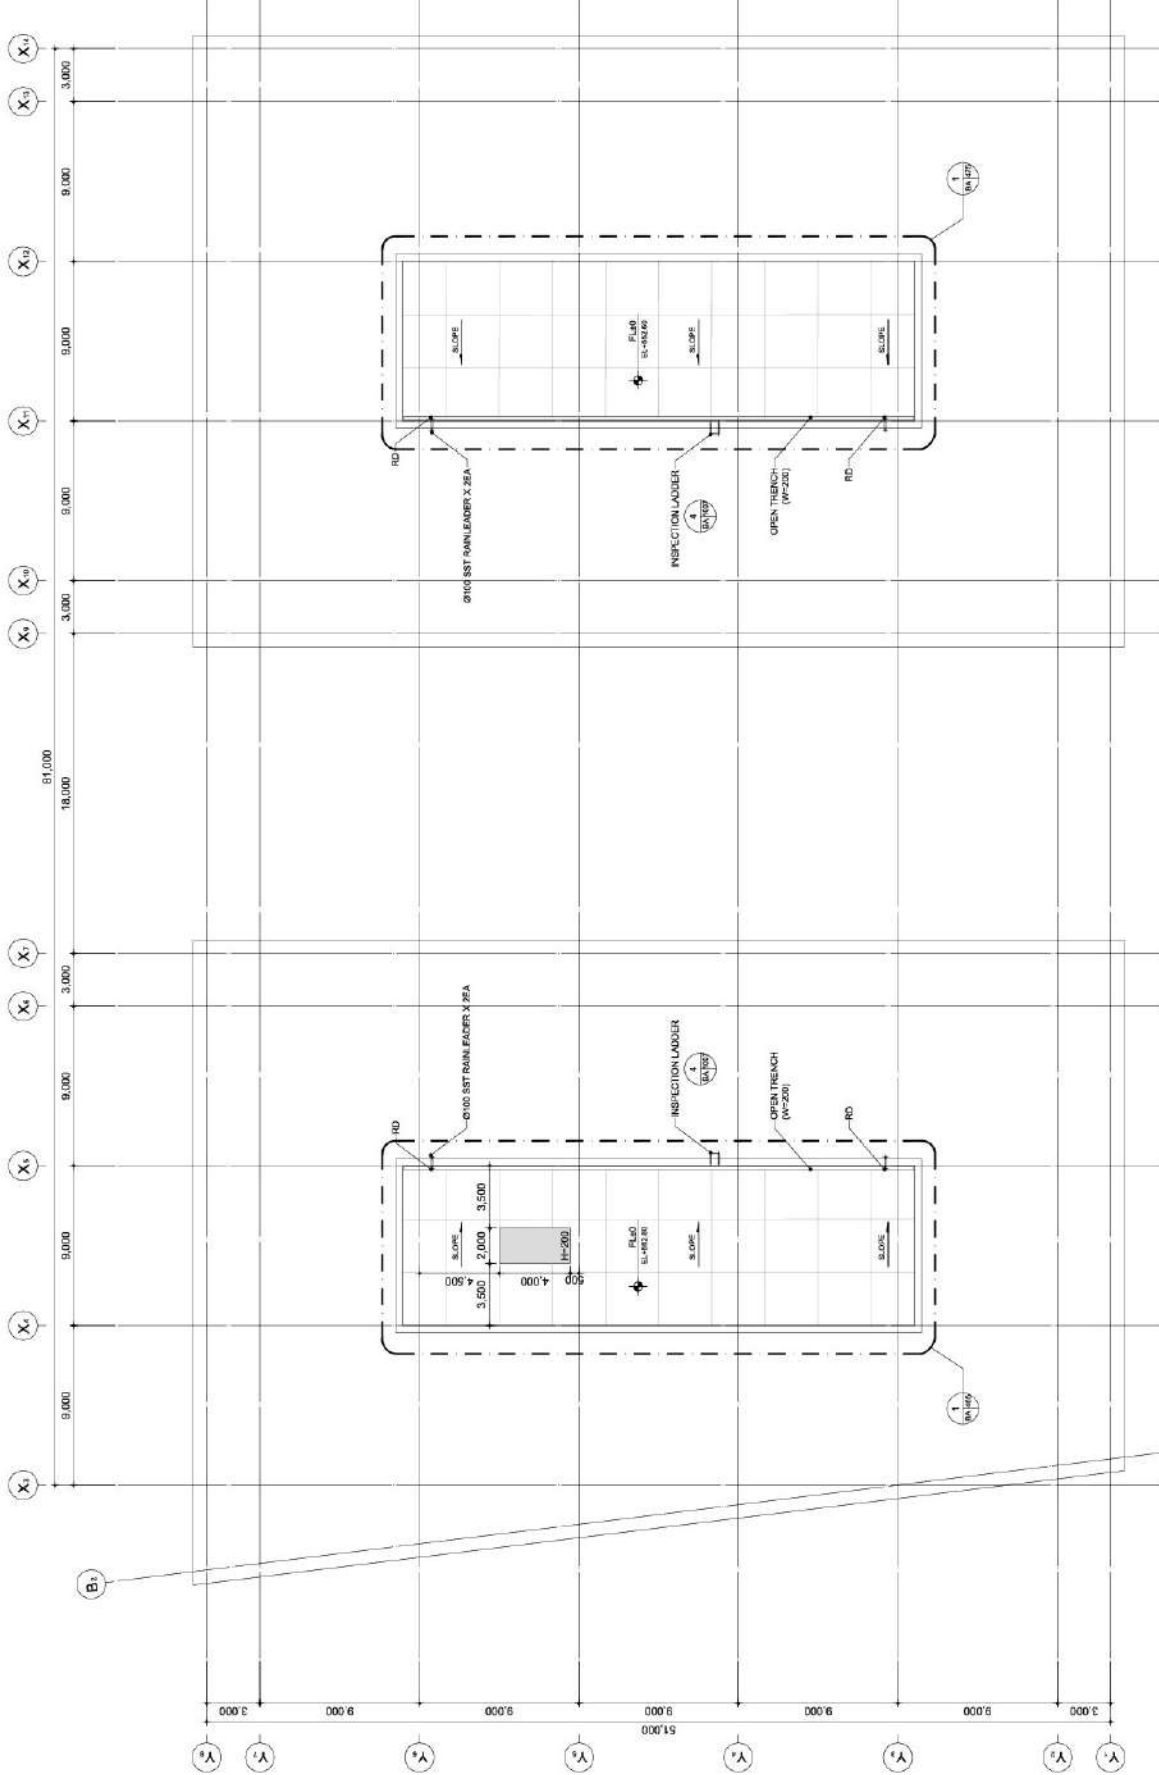

1 ENLARGED FLOOR PLAN(ROOF TOP)
Scale: 1/150