
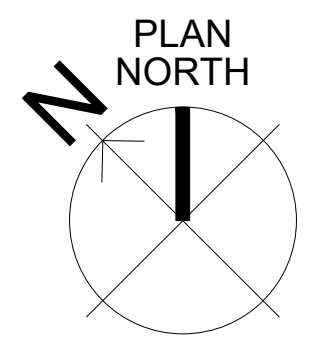


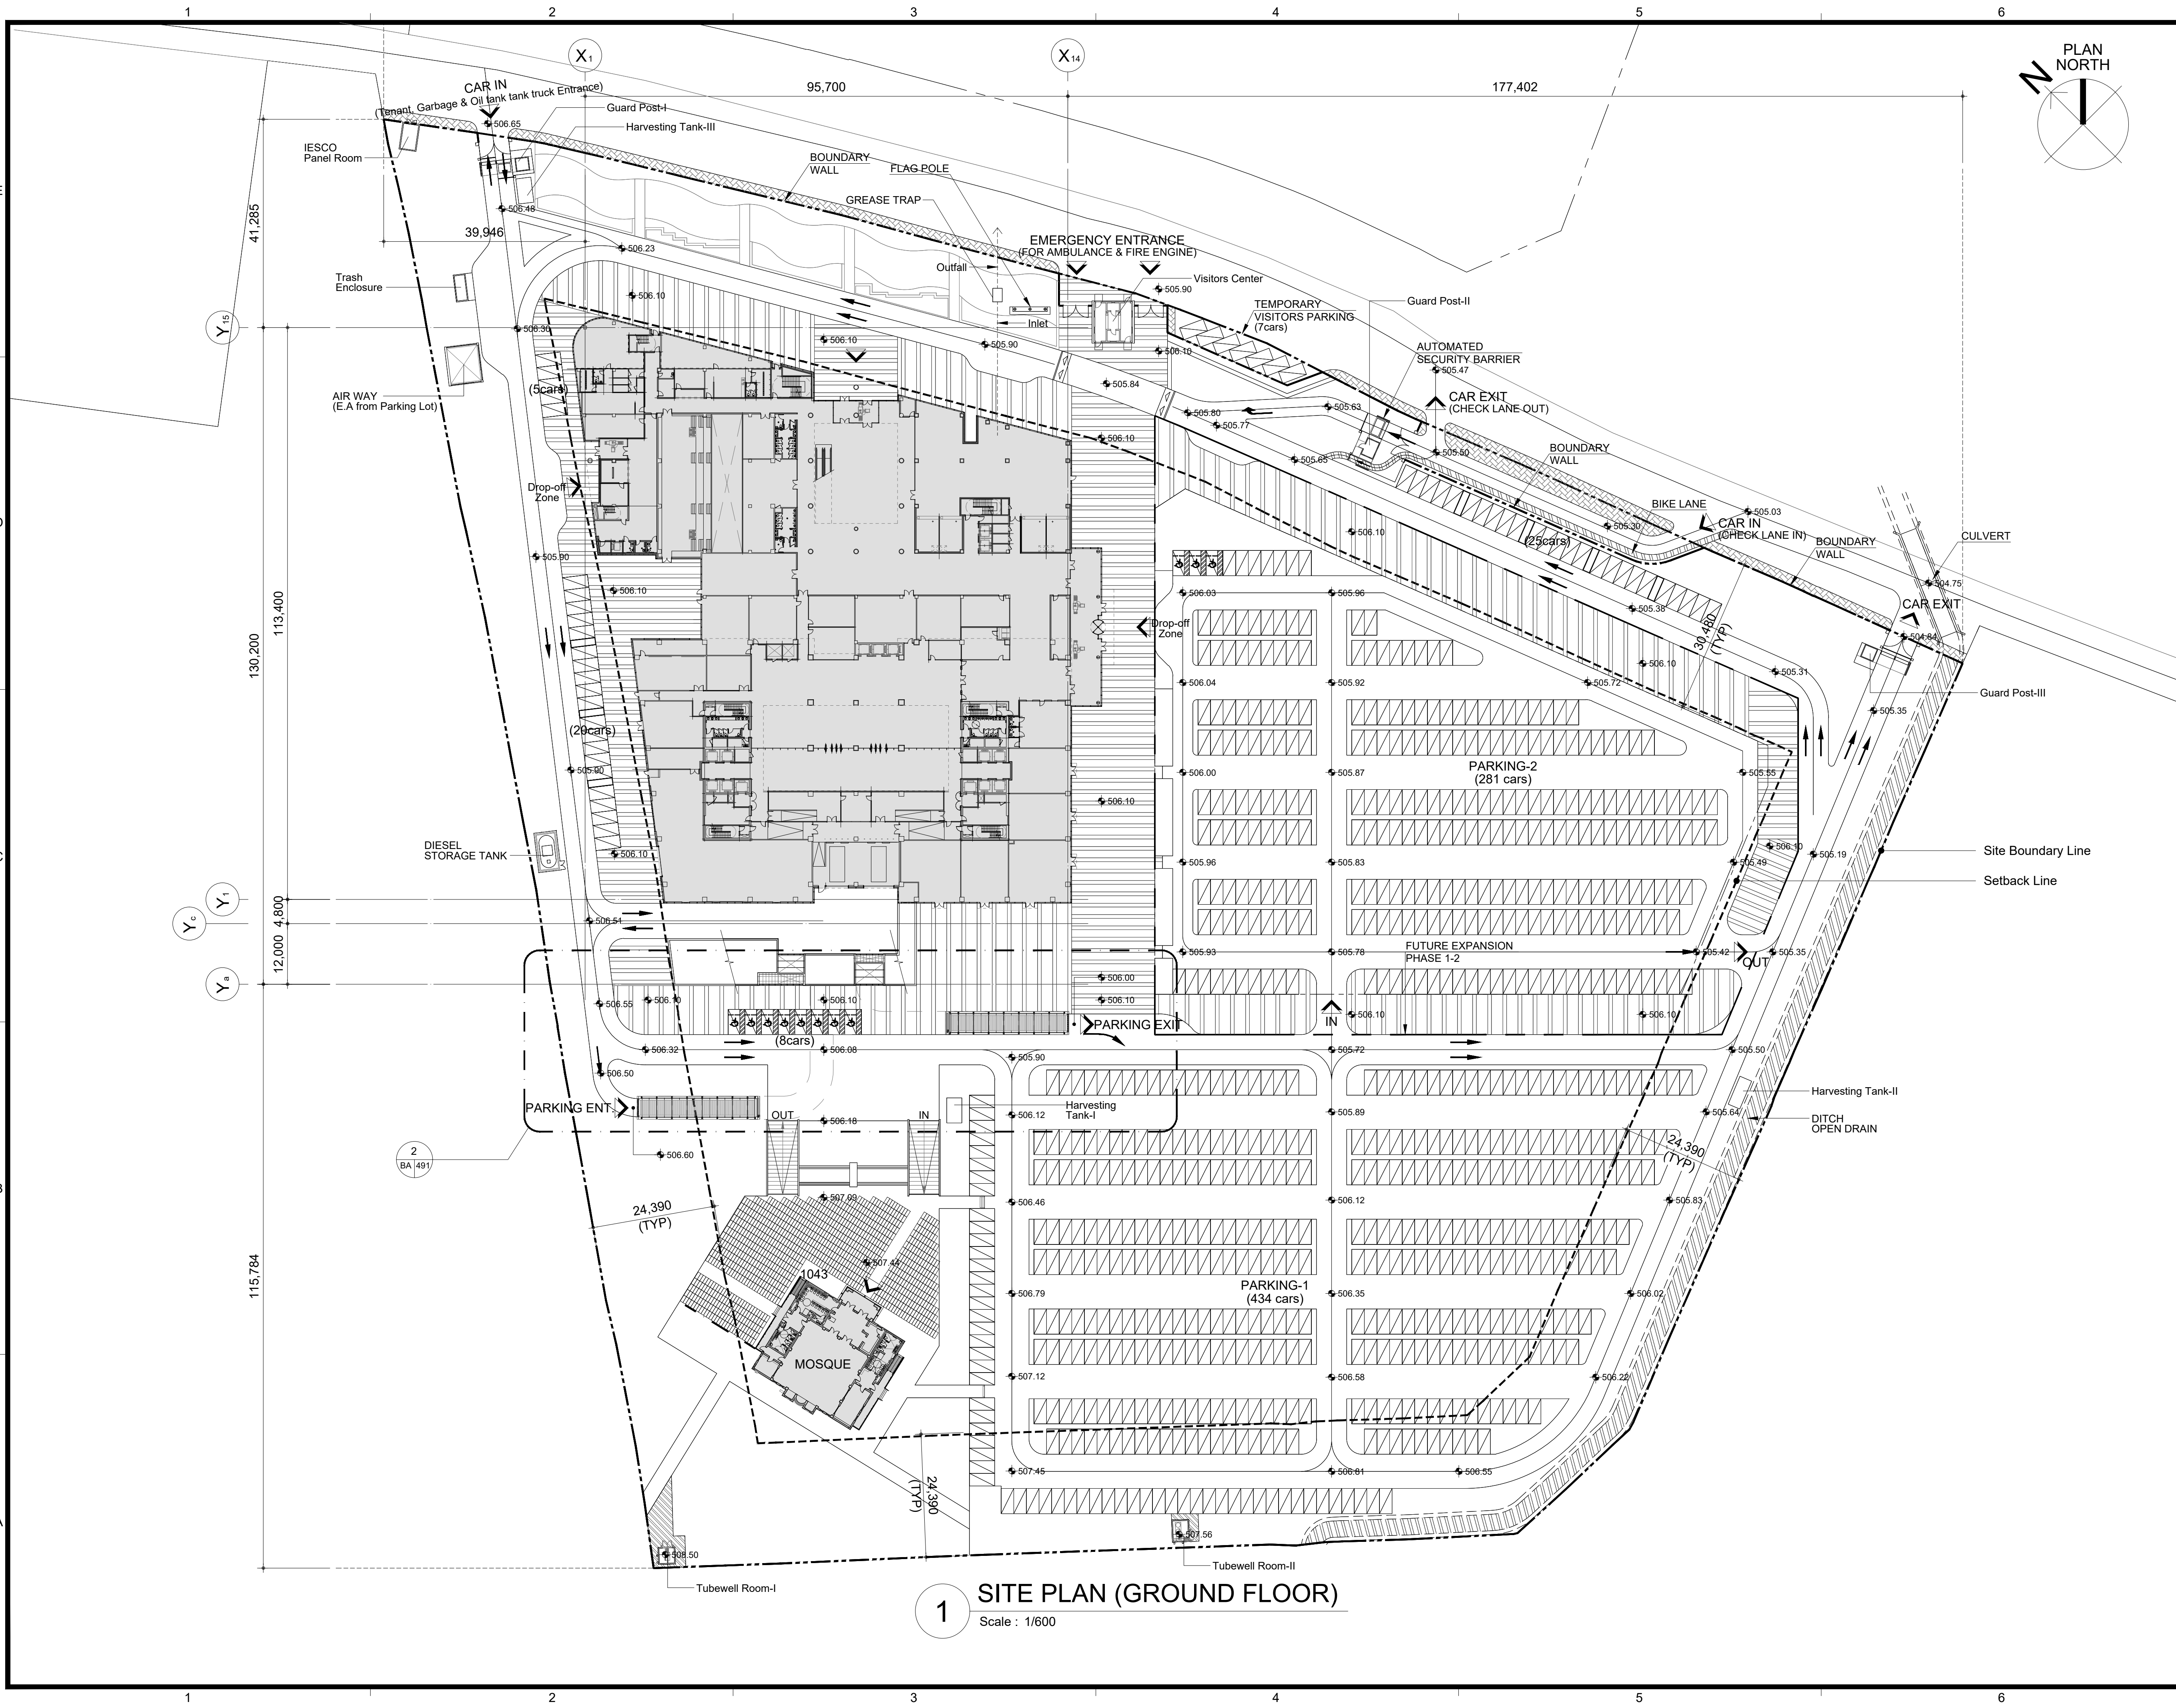

Ministry of Information Technology
Government of Pakistan

PROJECT TITLE
**TECHNOLOGY PARK
DEVELOPMENT
PROJECT ISLAMABAD**

NOTE

NO.	DESCRIPTION	DATE	APPR.
REVISIONS			

SUNJIN
ENGINEERING & ARCHITECTURE

DAEYONG UBITEC Co.,LTD.



NEC
National Engineering Corporation

NAME OF DRAWING SITE PLAN (GROUND FLOOR)			
DATE	DESIGNED BY		
Oct. 2020	Lee, Dongho		
SCALE	CHECKED BY		
A1 1/600 A3 1/1,200	Lee, Jaeho		
DRAWN BY	APPROVED BY		
Lee, Dongho	Kang, Jeonung		

DRAWING NO.	BA-042		
FILE NAME	SHEET NO.		
PROJECT NUMBER s2019a007	000		

1 SITE PLAN (GROUND FLOOR)
Scale : 1/600